# Wade's Dairy

# Milkhouse Upgrade & Bottling Addition

5475 West 1400 North Warren, Utah 84404 Parcel# 150200014



Vicinity Map

Remuda Golf Course and Driving Range

# Applicants:

# Permanent Structures:

Last Cow, LLC. 5545 W 1400 N Warren, Utah 84404

# Tenant Finishes:

Wade's Dairy 5249 W 1400 N Warren, Utah 84404

# Project Address:

5475 W 1400 N Warren, Utah 84404

# Lot Area:

5.63 ACRES

All work to reflect local agriculture structure building codes.

Lot without individual septic system.

Plans reflect future septic system addition.

Employees to use portable toilet during business hours.

Culinary water to be provided by Warren Water District.

Existing electric, gas and land based telephone service located on the lot.


Lot Owner to be responsible for any cost of new connection to services.

### Sheet List Table

Sheet#	Page	Sheet Title		
1	C100	Cover Sheet & Plot Plan		
2	A100	Project Notes		
3	A102	Existing Conditions		
4	A103	Elevations		
5	A104	Floor Plan		
6	A105	Slab Plan		
フ	A106	Layout Plan		
8	A107	Sections		
9	A108	Details		
10	M100	Mechanical Plan		
11	M101	Mechanical Notes		
12	E100	Electrical Plan		
13	E101	Electrical Notes		
14	E102	Electrical Notes		



t 1400 North Utah 84404 et & Plot Plan

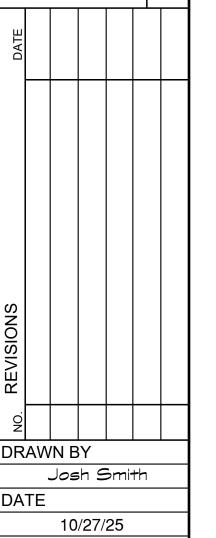

Cover Sheet & Plot Plan

1/32" = 1'

C100

of **14** 

SCALE

#### Introduction:

This drawing set consists of plans for the renovation and construction of the Wade Dairy facility at 5475 W. 1400 N. Weber County, Utah.

The company will be providing dairy cow milk production and bottling in the facility.

Their hours of operation will be determined by cow milking schedules and the timeframe need for bottling daily worker count of 1-5 individuals.

Milk and milk products produced on site for retail to be distributed to the retail location of Wade's Dairy.

This facility will be built and furnished to meet the requirements for dairy production.

This facility will be supplied with on-site city water, a on-site wastewater septic system, propane gas, and 2 phase electricity.

There will be an addition attached at the side of the facility to shelter compressors, vacuums and tanks called the equipment room. This will have a double walk-through door to the rear for ease of equipment loading, staging and installing.

### Requirements:

All work and materials used in the processes to construct this facility must comply with but not limited to the following codes, laws and requirements:

2021 International Building Code (IBC)

2021 International Fuel Gas Code (IFGC)

2021 International Mechanical Code (IMC)

2021 International Property Maintenance Code (IPMC)

National Fire Protection Association (NFPA) 101

Life Safety Code 202

Utah Department Of Agriculture Requirements For Pasutrized Milk Ordinance: Grade A Farm Construction.

Utah Dairy Act

Utah Rule R70-330-4

Utah Food Safety Rule.

# General Notes:

Compliance with codes, rules, regulations, and ordinances governing the work shall be made and enforced by the general contractor.

General contractor shall verify all existing conditions and dimensions prior to construction.

Note that all written dimensions take precedence over scale.

Manufacturer's specifications for installation of materials shall be followed.

Workmanship throughout shall be of the best quality of the trade involved and the general contractor shall coordinate the work of the various trades to expedite the job in a smooth and continuous process.

# Foundation Notes:

Drainage tiles, gravel or crushed stone drains, or mechanical means into an approved drainage materials shall be installed at or below the area to be protected and shall discharge by gravity perforated pipe or other approved systems or system.

Concrete footings required under all foundation walls, bearing walls and posts.

### General Concrete Notes:

Walls, foundations and other concrete not exposed to the weather = 2,500 psi.

Interior slabs on grade, except garage floor slabs = 2,500 psi.

Foundation exterior walls exposed to the weather = 3,000 psi.

weather = 3,500 psl.

Porches.slabs. and steps exposed to the

Emergency floor drains at water heaters, laundries, garages, etc. req. a trap seal primer or deep seal trap. IPC Sec. 1002.4.1.

All exterior doors shall have a floor or landing on each side of the door. The floor or landing at a door shall not be more than 1.5 inches lower than the top of the threshold. If the door is not a req. exit door the landing shall not exceeded 8" from top of threshold.

All landings shall be not less than 36" wide, measured in the direction of travel.

# Concrete Floor Slab:

A 6-mil polyethylene or approved vapor retarder with joints lapped not less than 6" shall be placed between the concrete floor slab and the base course or the prepared sub-grade where no base course exists.

Exception: The vapor retarder is not required for the following:

1) Garages, utility buildings and other unheated accessory structures.

2) For unheated storage rooms having an area of less than 10 sq. ft.

3) Driveways, walks, patios and other flatwork not likely to be enclosed and heated at a later date.

4) Where approved by the building official, based on site conditions.

# Framing Notes:

Bottom plate anchor bolts shall be 3/8"x5" wedge bolts with a 3"x3"x1/4" washer at each bolt. if slotted washer is used, add cut washer.

Wall Dbl top plates shall be 2x min. and shall lap 36" min. at all splices with (12) 16d nails staggered each side of splice.

Where plates do not lap, provide CS 16'X32' strap to splice plates, align wall stud with plate joints

Attach (2) ply headers together with (3)16d at 12" o.c. [(2) 1gd ok for 2x6 headers]. Use (3) 16d at 12" o.c. each side for (3) ply headers. Use (4) 16d at (2) and (3) ply headers when header height is greater than 11". attach (4) ply headers together with (2) "through bolts at 16" o.c. or (2) SDS 1/4"x 6" screws at 16"o.c. each side of header.

Wall Sheathing: 7/16" APA rated OSB. See plan.

Provide edge nailing at all supported and blocked panel edges 6" o.c. and field nail all wall studs 12" o.c. with 2" galvanized ring shank nails and as per details.

# Bathroom Notes:

A mechanical ventilation system shall be req. The ventilation rates shall be 50 cfm. for continuous ventilation.

Toilet, bath and shower areas to be finished with a nonabsorbent surface in accordance with IRC P307

### Mechanical General Notes:

Mechanical contractor to provide combustion air to furnace area in accordance with local natural gas specifications.

Combustion air to be brought into building from outside. 2-ducts provided, placed at 12"

Combustion air shall be supplied by two (2) vertical openings, each with I sq. In. per 4,000 BTU/h of the total inputting rating of all appliances within the space.

OR Combustion air shall be supplied by two (2) horizontal openings, each with I sq. n. per 3,000 BTU/h of the total input rating of all appliances within the space.

One opening must be in the top 12' of room IRC G2407.6.2

Water heaters shall be anchored or strapped in the upper one-third and in the lower one-third of the appliance to resist a horizontal force equal to one-third of the operating weight of the water heater, acting n any horizontal direction, or in accordance with the appliance manufacture's recommendations. P2801.7 4 IRC P2801.7

The mechanical room shall be enclosed, sealed and insulated in accordance with IECC NIIO2.4.4

### Appliance Anchorage:

Water heaters shall be anchored or strapped to resist horiz. movement.

Strapping shall be at points within the upper one-third and lower one-third of the appliance's horiz.dimensions.

At the lower point, the strapping shall maintain a min. distance of 4 Inches above the controls.

# Appliances In Attics:

Attics containing appliances requiring access shall have an opening and a clear and unobstructed passageway large enough to allow removal of the largest appliance, but not less than 30 inches high and 22 inches wide and not more then 20 feet long when measured along the centerline of the passageway from the opening to the appliance.

The passageway shall have 'continuous solid' flooring in accordance with chapter 5 not less then 24 inches wide.

A level service space at least 30 Inches deep and 30 Inches wide shall be present along all sides of the appliance where access is required the clear access opening dimensions shall be a minimum of 20 Inches by 30 inches, where such dimensions are large enough to allow removal of the largest appliance. I.R.C. M1305.1.3

# Supply/Return Insulation:

Supply and return air ducts shall be insulated to a min. of r-8 when located outside of the thermal envelope (unconditioned attics). IECC 403.2

# Gas Piping:

Gas piping shall not be Installed in or through a ducted supply, return, exhaust, clothes chute, chimney, or elevator shaft.

Gas piping shall not penetrate building foundation walls at any point below grade (IRC G2415.6)

Appliances shall not be located in bathrooms, storage rooms or a space that opens into such rooms. See exceptions (IRC G2406.2).

Gas piping installed underground beneath buildings Is prohibited except where the piping is encased in a conduit. Such conduit shall extend not less then 4' outside the building, shall be vented above grade to the outdoors and shall be Installed so as to prevent the entrance of water or insects. (IRCG2415.14)

#### Fire Protection:

Provide 5/8' type "x"gyp board with a minimum of level 1 finish, on all the ceilings of interior framina

All beams and structural members shall be protected with 5/8" gyp. board in below attic area.

Fire blocking at stud cavities that are greater than 8', all flue's, chases and dropped ceilings.

### Exhaust Systems:

Dryer exhaust systems shall convey the moisture to the outdoors and shall terminate on the outside of the building.

Screens shall not be installed at the duct terminal.

Ducts shall have a back draft damper.

The max. length of clothes dryer exhaust duct shall not exceed 25 feet from the dryer location to the wall or roof termination.

The max. length of the ducts shall be reduced 2.5 feet for each 45 degree bend and 5 feet for each 90 degree bend. Metal ducting shall be sealed and secured every 12 feet.

### Dryer Duct:

Dryer duct shall terminate outdoors and shall not exceed a total combined horizontal and vertical length of 35'.

Maximum length of duct shall be reduced 2-1/2' for each 45° bend or 5' for each 90 bend.

Duct shall be a min. nominal size of 4" I.R.C.M502.4.4

# Energy Notes:

IECC R402.2.4- The attic access door from the conditioned space to unconditioned space shall be weather stripped and insulated to a level equivalent to the insulation on the surrounding surfaces.

# Condensate Disposal:

Condensate from all cooling coils or evaporators shall be conveyed from the drain pan outlet to an approved place of disposal.

Condensate shall not discharge Into a street, alley or other areas so as to cause a nuisance. I.R.C. MI411.3

A secondary drain or auxiliary drain pan shall be required for each cooling or evaporator coil where damage to any building components will occur as a result of overflow from the equipment drain pan or stoppage in the condensate drain piping.

Drain piping shall be a minimum of 3/4" nominal size. I.R.C.MI4II.3.I

# HVAC Outlet:

A 125-volt, single-phase, 15- or 20-amp rated receptacle outlet shall be installed at an accessible location for the servicing of heating, air-conditioning and refrigeration equipment. The receptacle shall be located on the same level and within 25 feet (7620 mm) of the heating, air-conditioning and refrigeration equipment. The receptacle outlet shall not be connected to the load side of the HVAC equipment disconnecting means. (E3q01.12)

# Temperature Limitations:

Where two or more non-metallic sheathed cables are installed together in the same space without maintaining space between them and where the opening they are installed in is filled with caulking, foam insulations, or other types of insulation, the conductors must be rated as required by IRC E3705.4.4.

# Small Appliance Receptacles:

All 125V 15-20 AMP receptacles Installed Inside or outside of facility shall be listed as tamper resistant.

### Draft Stopping:

In combustible construction where there is usable space both above and below the concealed space of a floor/ceiling assembly, draft stops shall be installed so that the area of the concealed space does not exceed 1,000 square feet (92.9 m2). R302.12

Draft stopping shall divide the concealed space into approximately equal areas. Where the assembly is enclosed by a floor membrane above and a ceiling membrane below, draft stopping shall be provided in floor/ceiling assemblies under the following circumstances: open-web or perforated members.

### Insulation

Building thermal envelope insulation:

Building insulation and vapor barrier will be included in the structure package and installed during the siding process.

Blown or sprayed ceiling insulation:

The thickness of blown in or sprayed ceiling insulation (fiberglass or cellulose) shall be written in Inches on markers that are installed at least one for every 300 ft2 throughout the attic space. The markers shall be affixed to the joists and marked with the minimum Initial installed thickness with a minimum of I inch high. Each marker shall face the attic access opening.

# Certificates:

Permanent certificates shall be posted in the mechanical room near the electrical distribution panel.

One certificate shall be completed by the insulation contractor. The certificate shall list the predominant R- values of insulation installed in or on ceiling/roof, walls, foundation (slab, basement wall, crawlspace wall and/or floor) and ducts outside conditioned spaces, and U-factors for fenestration.

The second certificate shall be completed by the mechanical contractor. The certificate shall list the type and efficiency of heating, cooling and service water heating equipment.

# Fire Warning Systems:

Multiple station smoke alarms shall be Installed Interconnected In such a manner that the actuation will activate all alarms in the entire facility.

# Carbon Monoxide Alarms:

Carbon Monoxide detectors shall be listed and comply with U.L. 2034 and shall be Installed in accordance with provisions of this code and NFPA 720.

All alarm devices shall be interconnected. The alarm shall be clearly audible in all rooms over all background noises with all intervening doors closed.

# Recessed Lighting:

Recessed lighting installed in the building envelope shall be IC rated and sealed to the interior finish. IRC NIIO2.4.5

BERT SMITH & SONS

General Contractors


2124 N 6700 W

Ogden, Utah 84404
(801)388-3253





Wade's Dairy Milking Parlor & Bottling 5475 West 1400 North Warren, Utah 84404

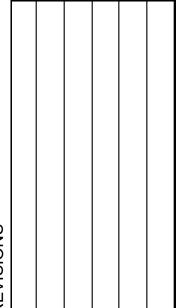

DRAWN BY

Josh Smith


DATE


Project Notes
SCALE

10/27/25

SHFFT

A100 2 of 14

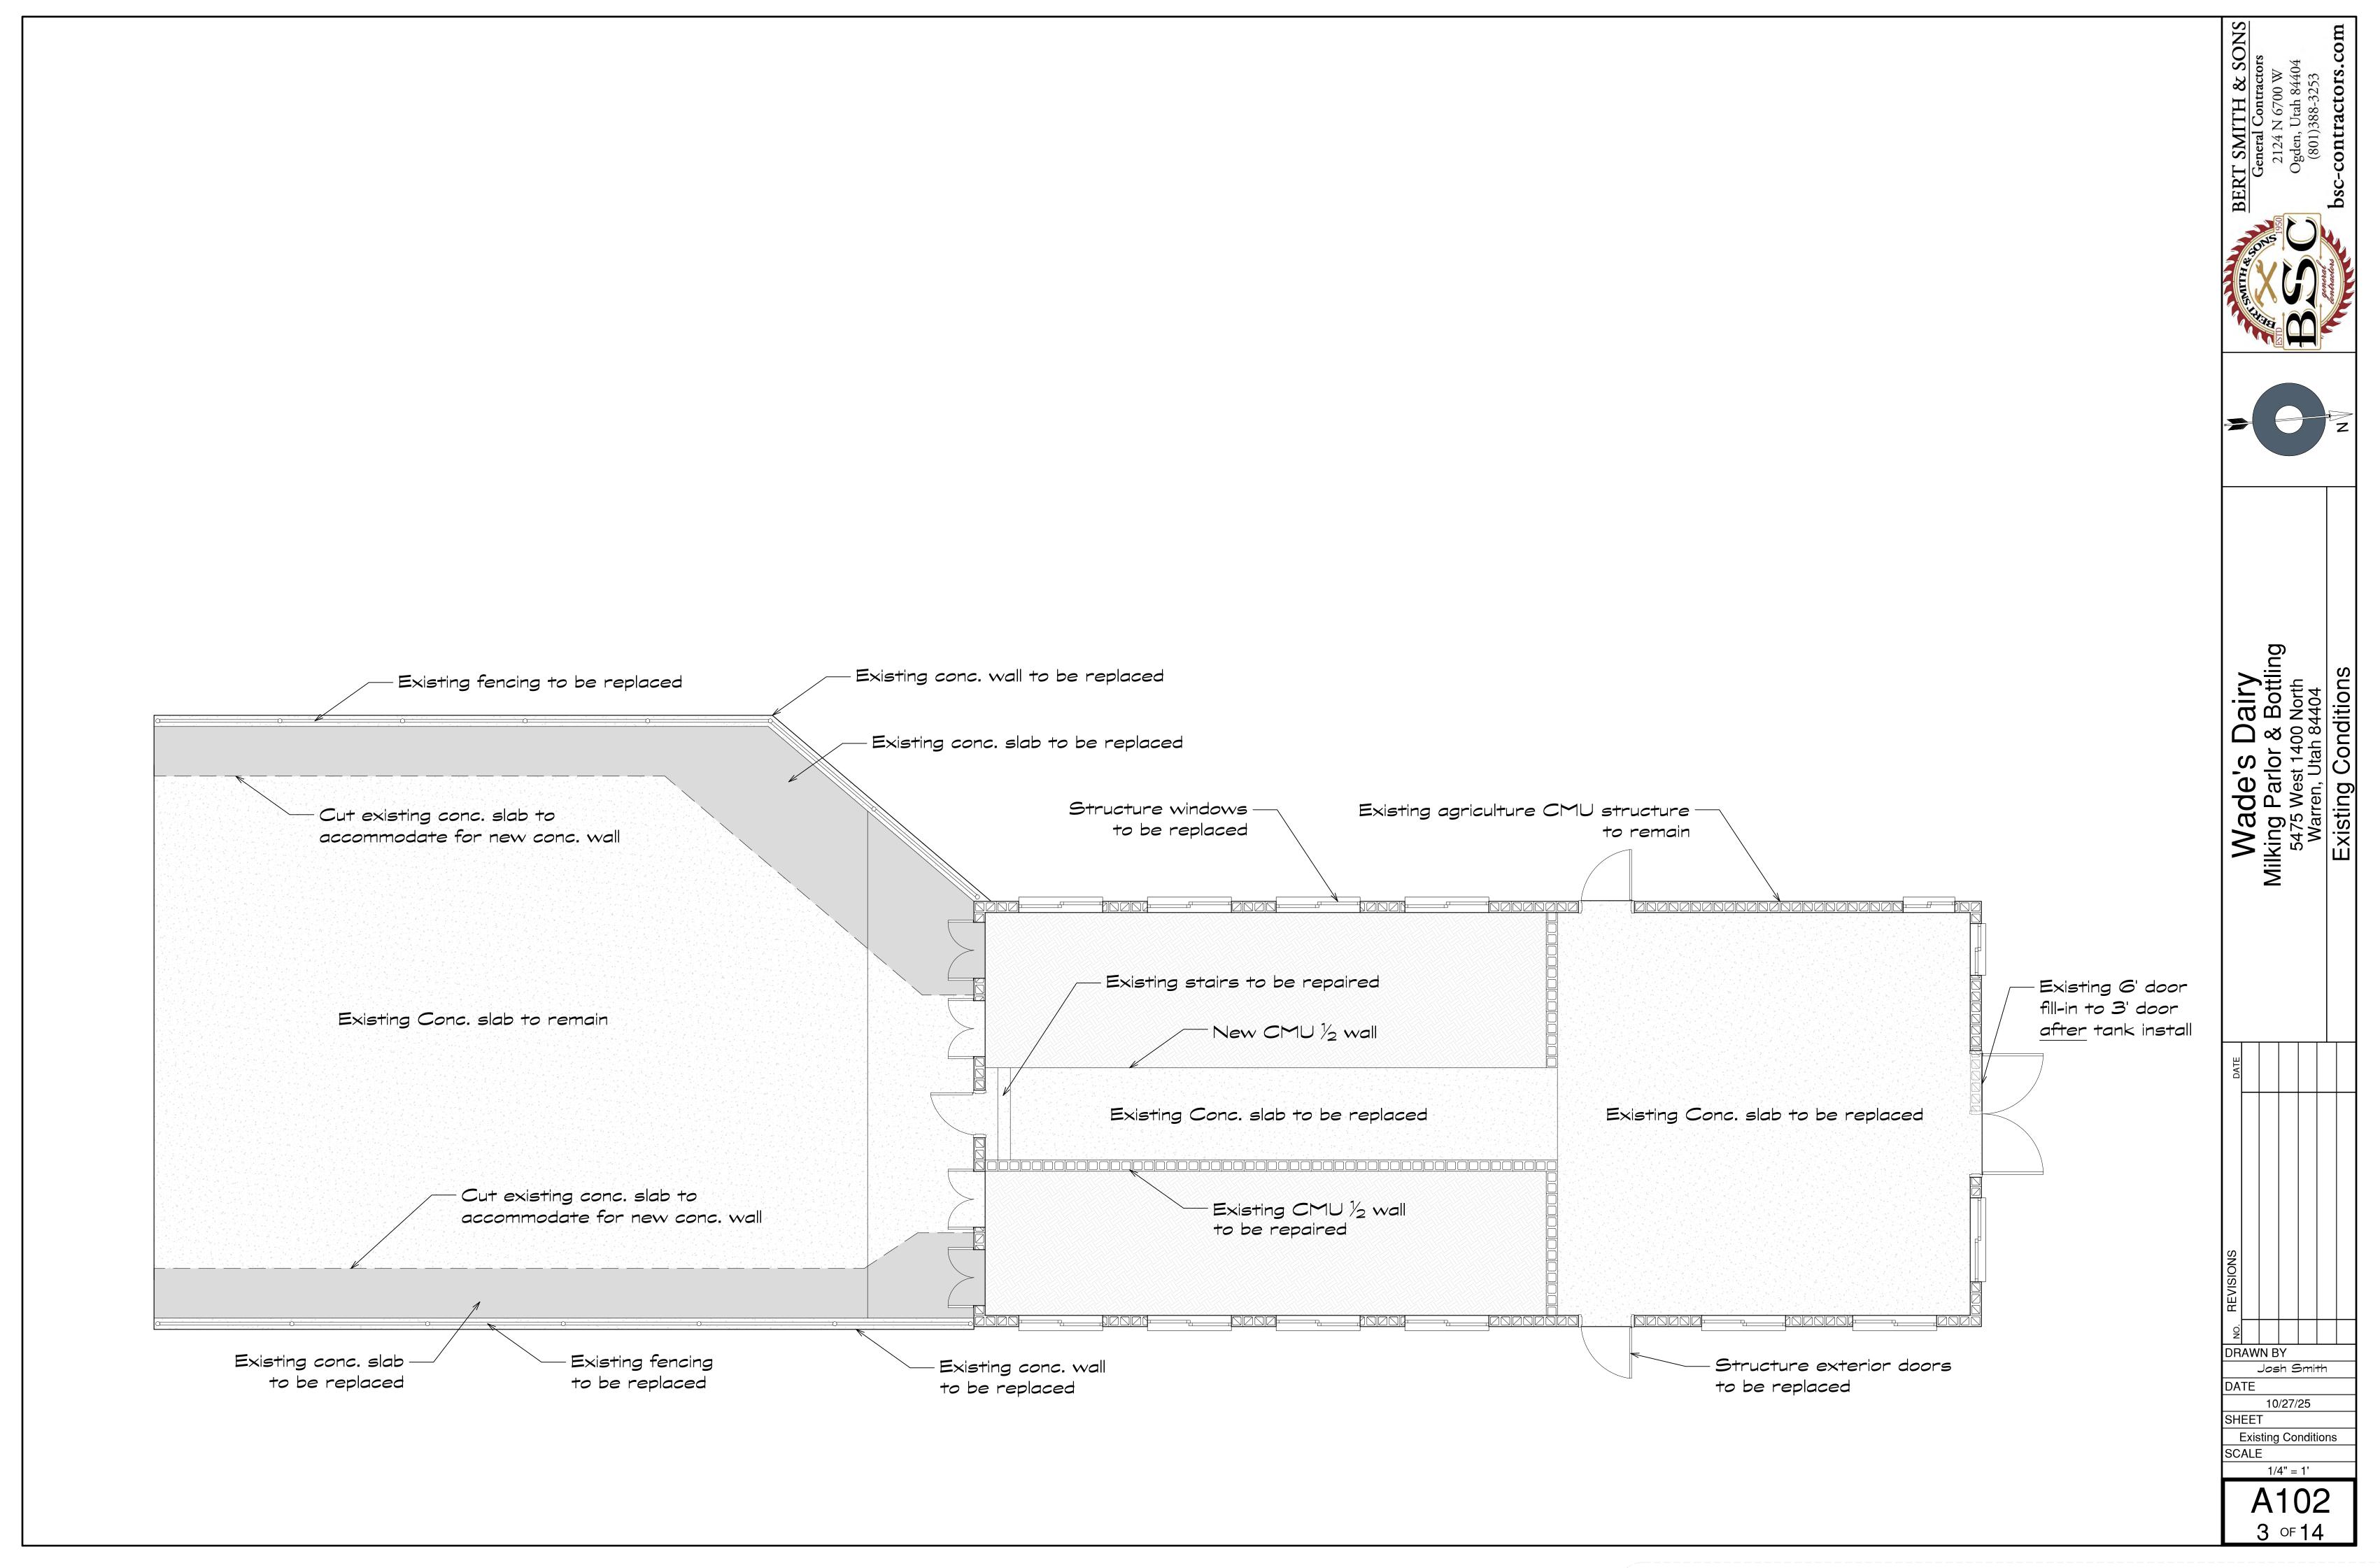

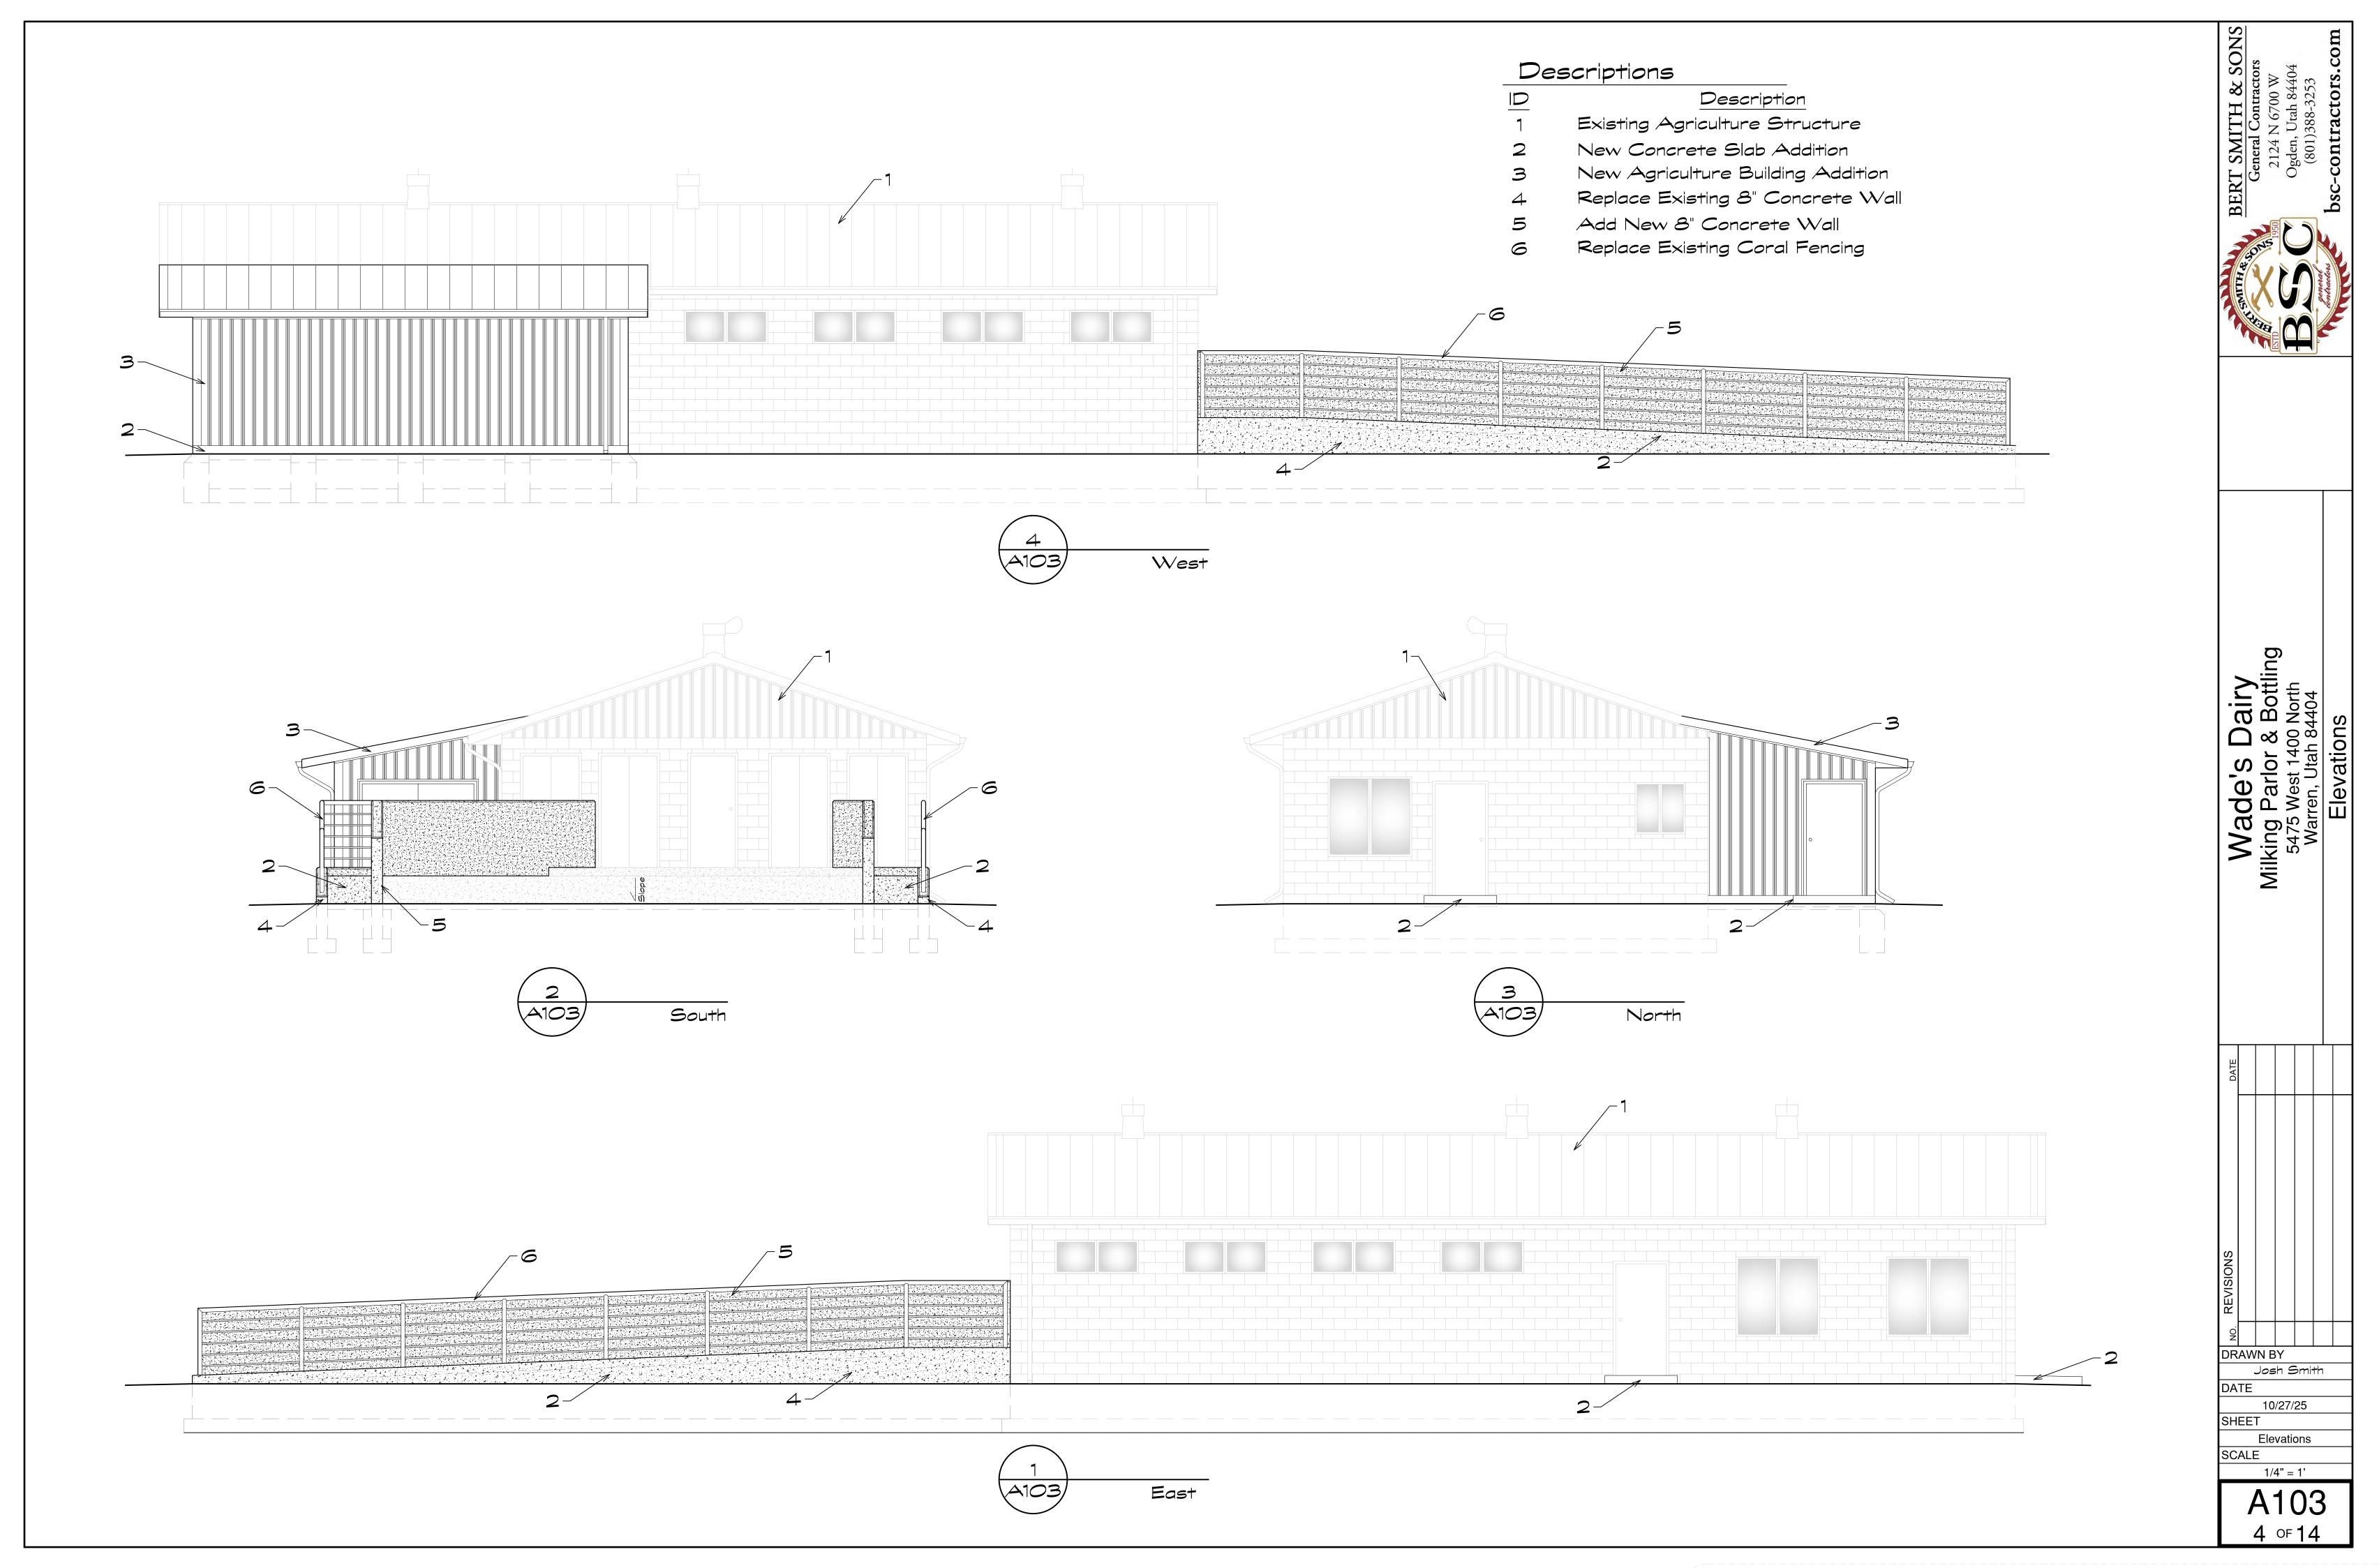

### Notes:

Restroom to be roughed-in. Finish will be future after septic system is installed.


# Room Schedules


Room ID	Room Description	Ceiling Height	Wall Finishes	Ceiling Finishes
(1)	Tank/ Inspection Room	9'-6"	PVC/ CMU	PVC
2	Filling Room	9'-6"	PVC	PVC
3	Bottle Wash Room	8' Vault	PVC	PVC
4	Equipment Room	8' Vault	PVC	PVC
5	Restroom (future)	9'-6"	PVC	PVC
6	Storage	9'-6"	PVC	PVC
7	Locker Room	9'-6"	PVC	PVC
<b>&amp;</b>	Milking Pit	10'	CMU	PVC
9	Cow Stand	7-6"	CMU	PVC
10	Holding Pen	Open	Concrete	Open

# Equipment Schedules Fauir ID Fauirment Description

Equip ID	Equipment Description
1	Milk Tank
2	Water Heater
3	Employee Lockers
4	Hand Sink
5	Cow Stand
6	Brisket Bar
7	Water Storage Tank
8	Vacuum Pump
9	Air Dryer
10	Air Compressor
11	Bottle Washer
12	Cooler
13	Bottle Filler
14	Receiver Jar
15	Transfer Pump
16	H/C Hose Bib
17	Portable Toilet (employee use)



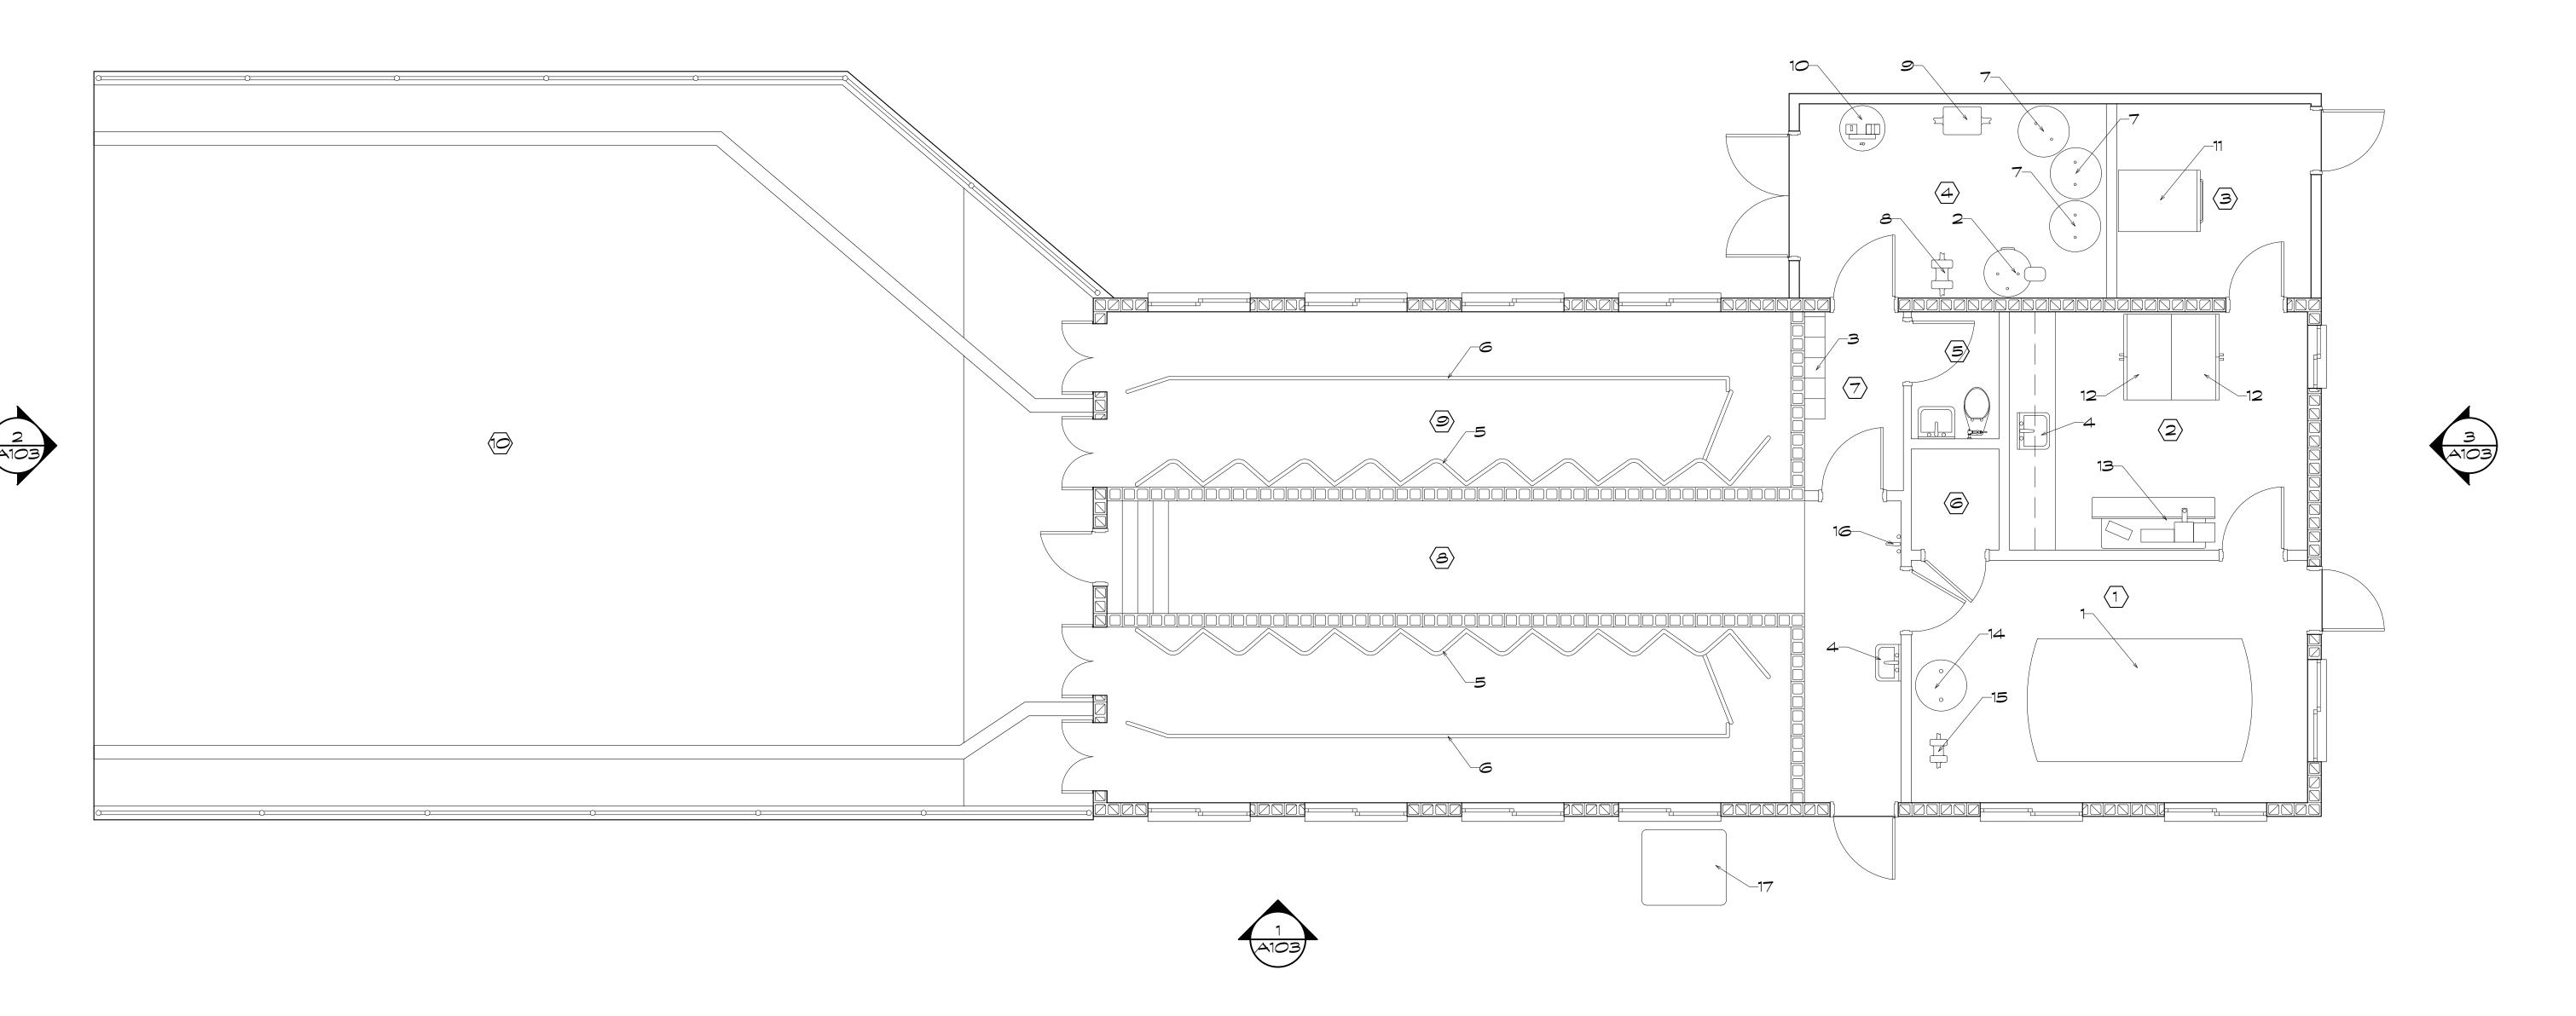


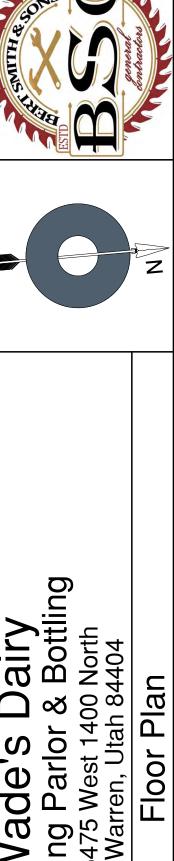


SHEET

Floor Plan SCALE 1/4" = 1'

A104 5 of 14

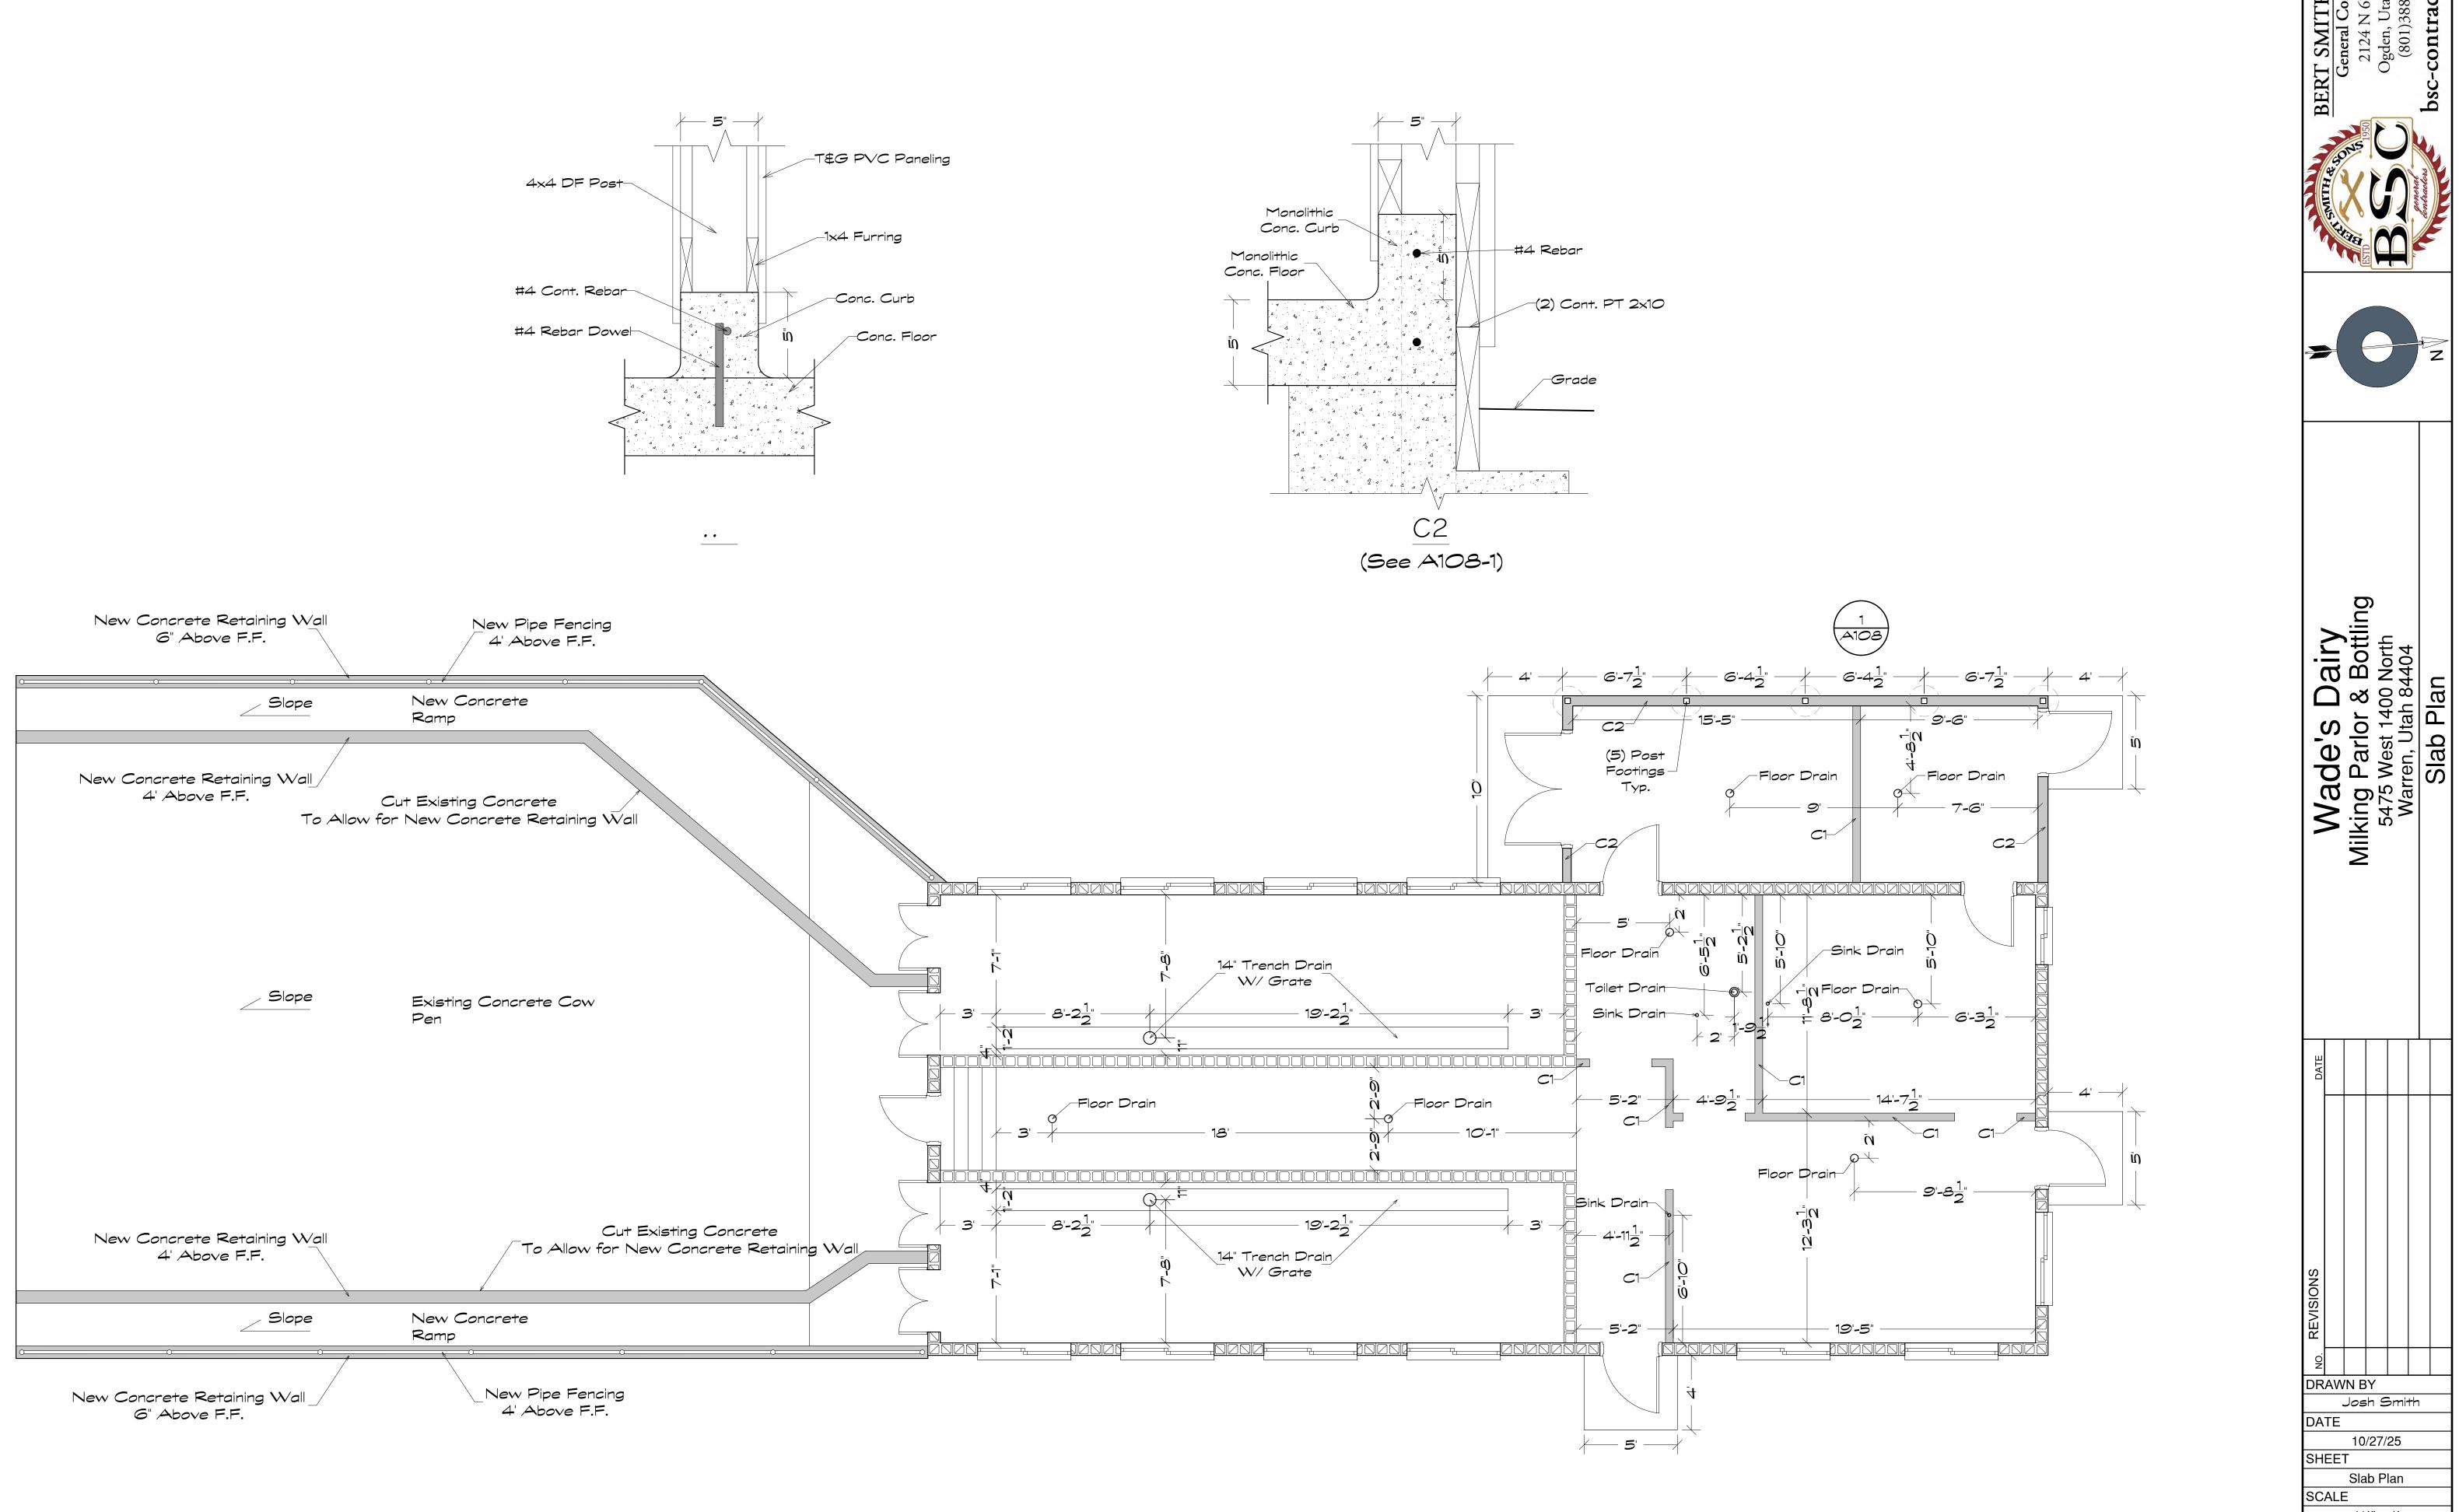

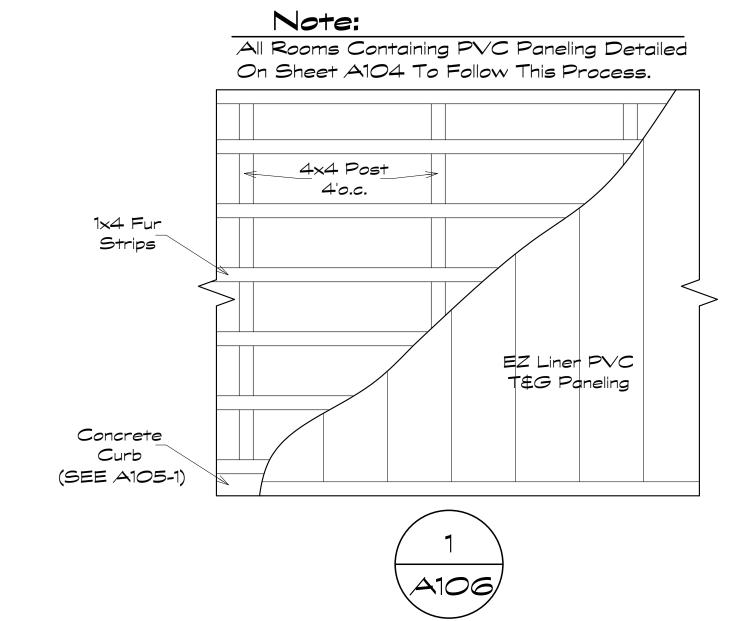



# Door Schedules


	or scriedules	
Door ID	Door Description	Door Size
1	Insulated Metal Personnel Door	3'0×6'8
2	Insulated Metal Personnel Door	3'4×6'8
3	Double Insulated Metal Personnel Door	6'0×7'0
4	Fiberglass Interior door	3'0×6'8
5	Insulated Metal Personnel Door	2'8×6'8
6	Double Ins. Metal Barn Door (others)	3'4×6'8


### Notes:


- 1. All framing and blocking to be dimensional lumber douglas fur #2 or better unless called otherwise.
- 2. All walls with cinder block finishes labeled on A104, to be faced with a food grade tile or substrate impervious to livestock.
- 3. All Exterior doors shall be air tight and impervious to insects.

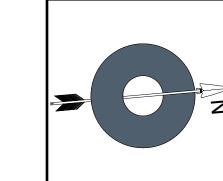

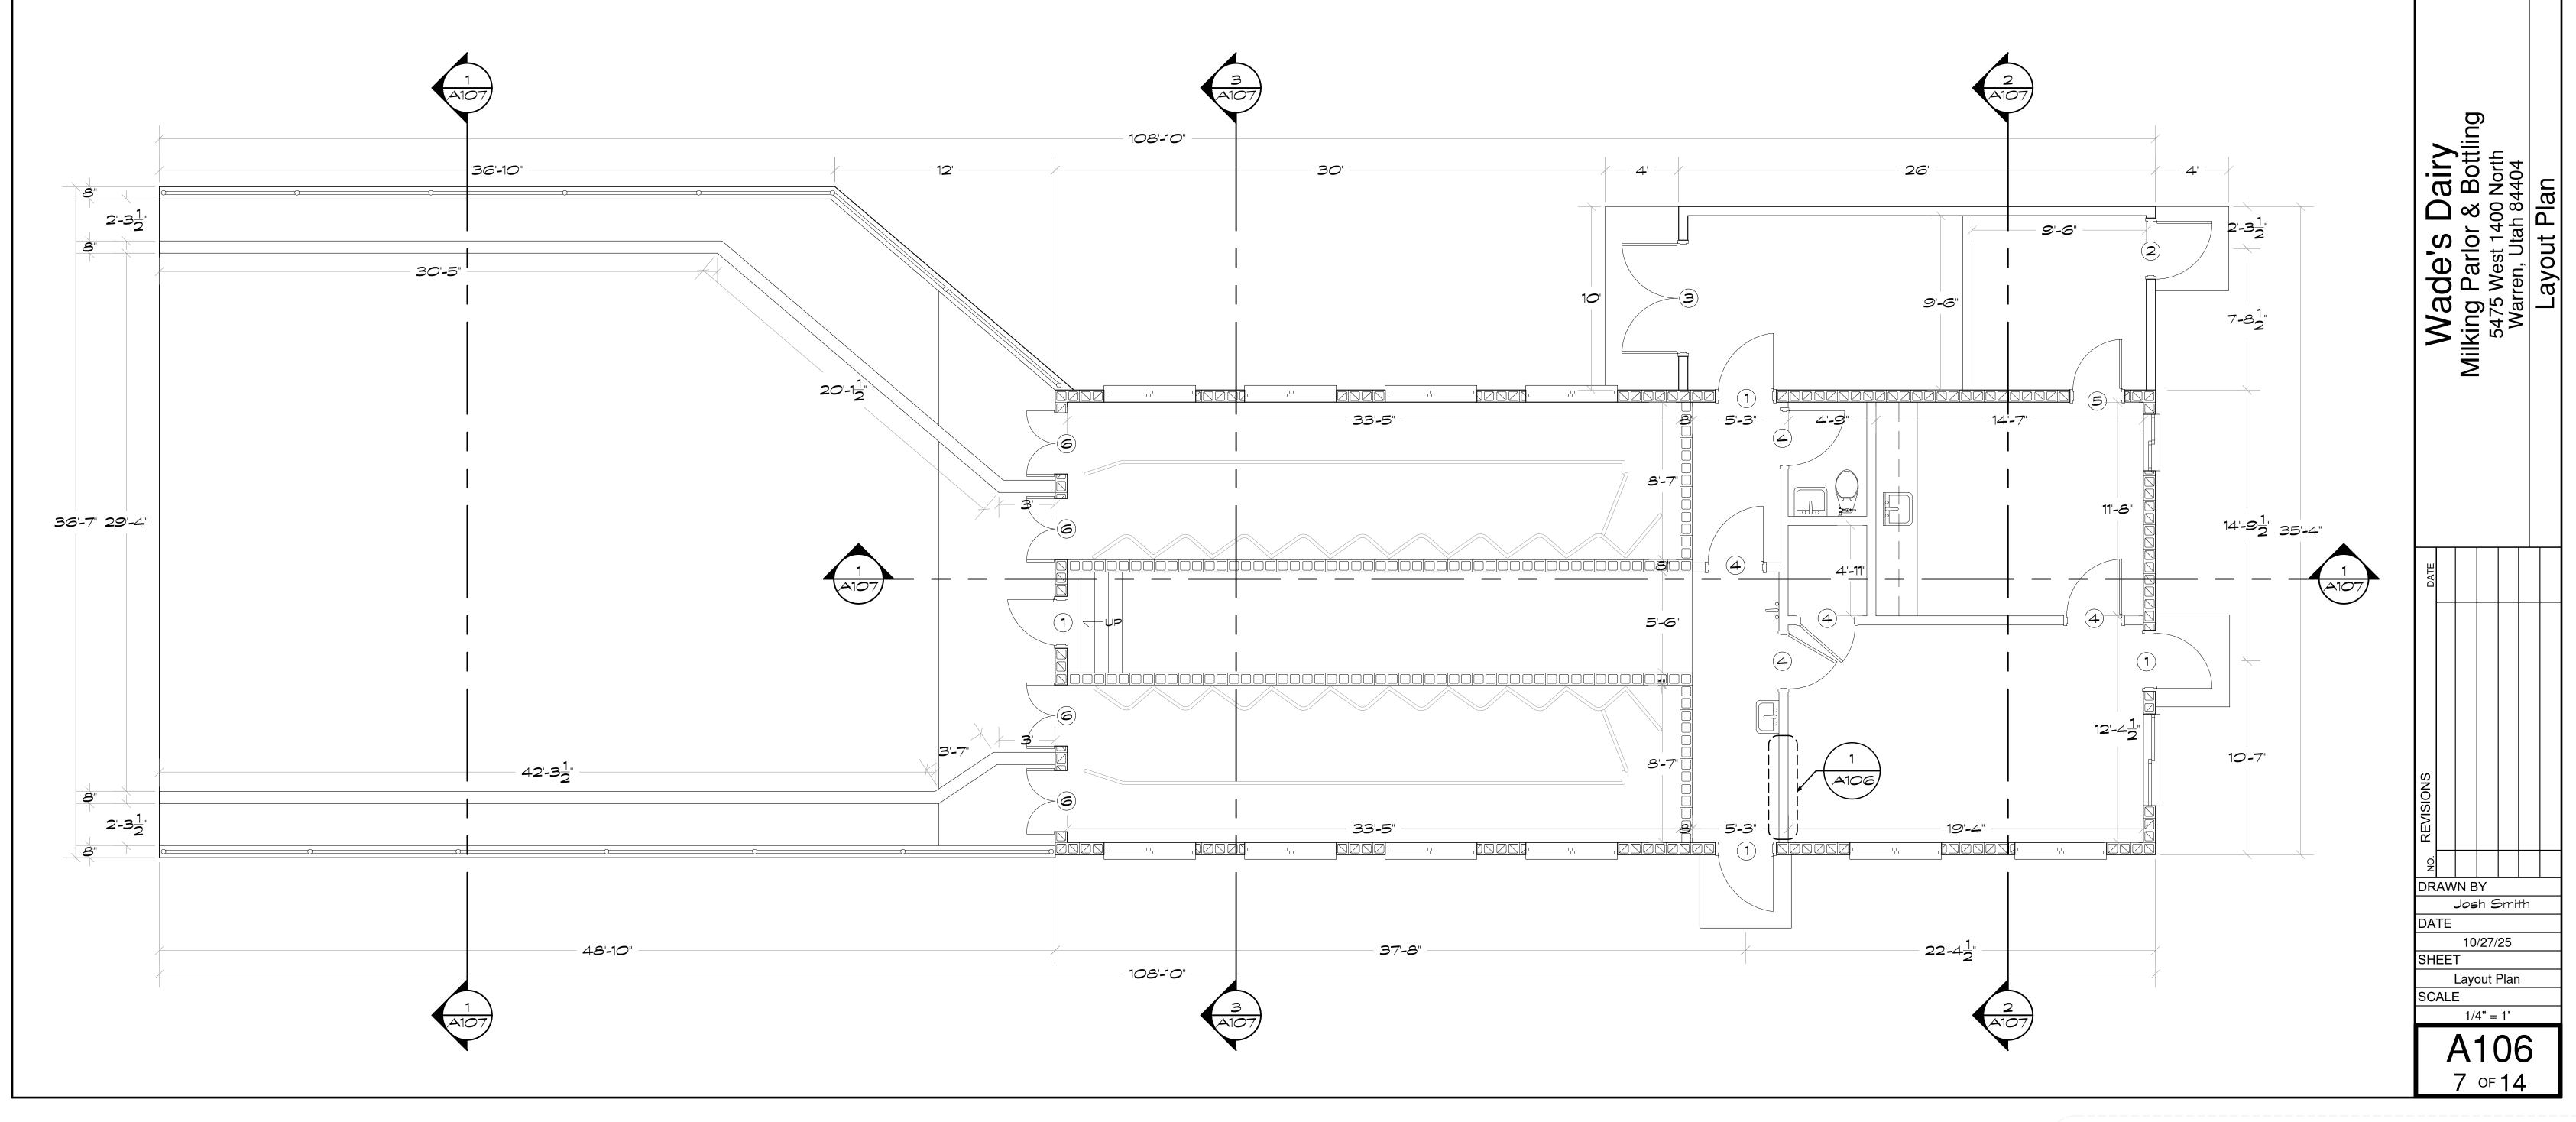

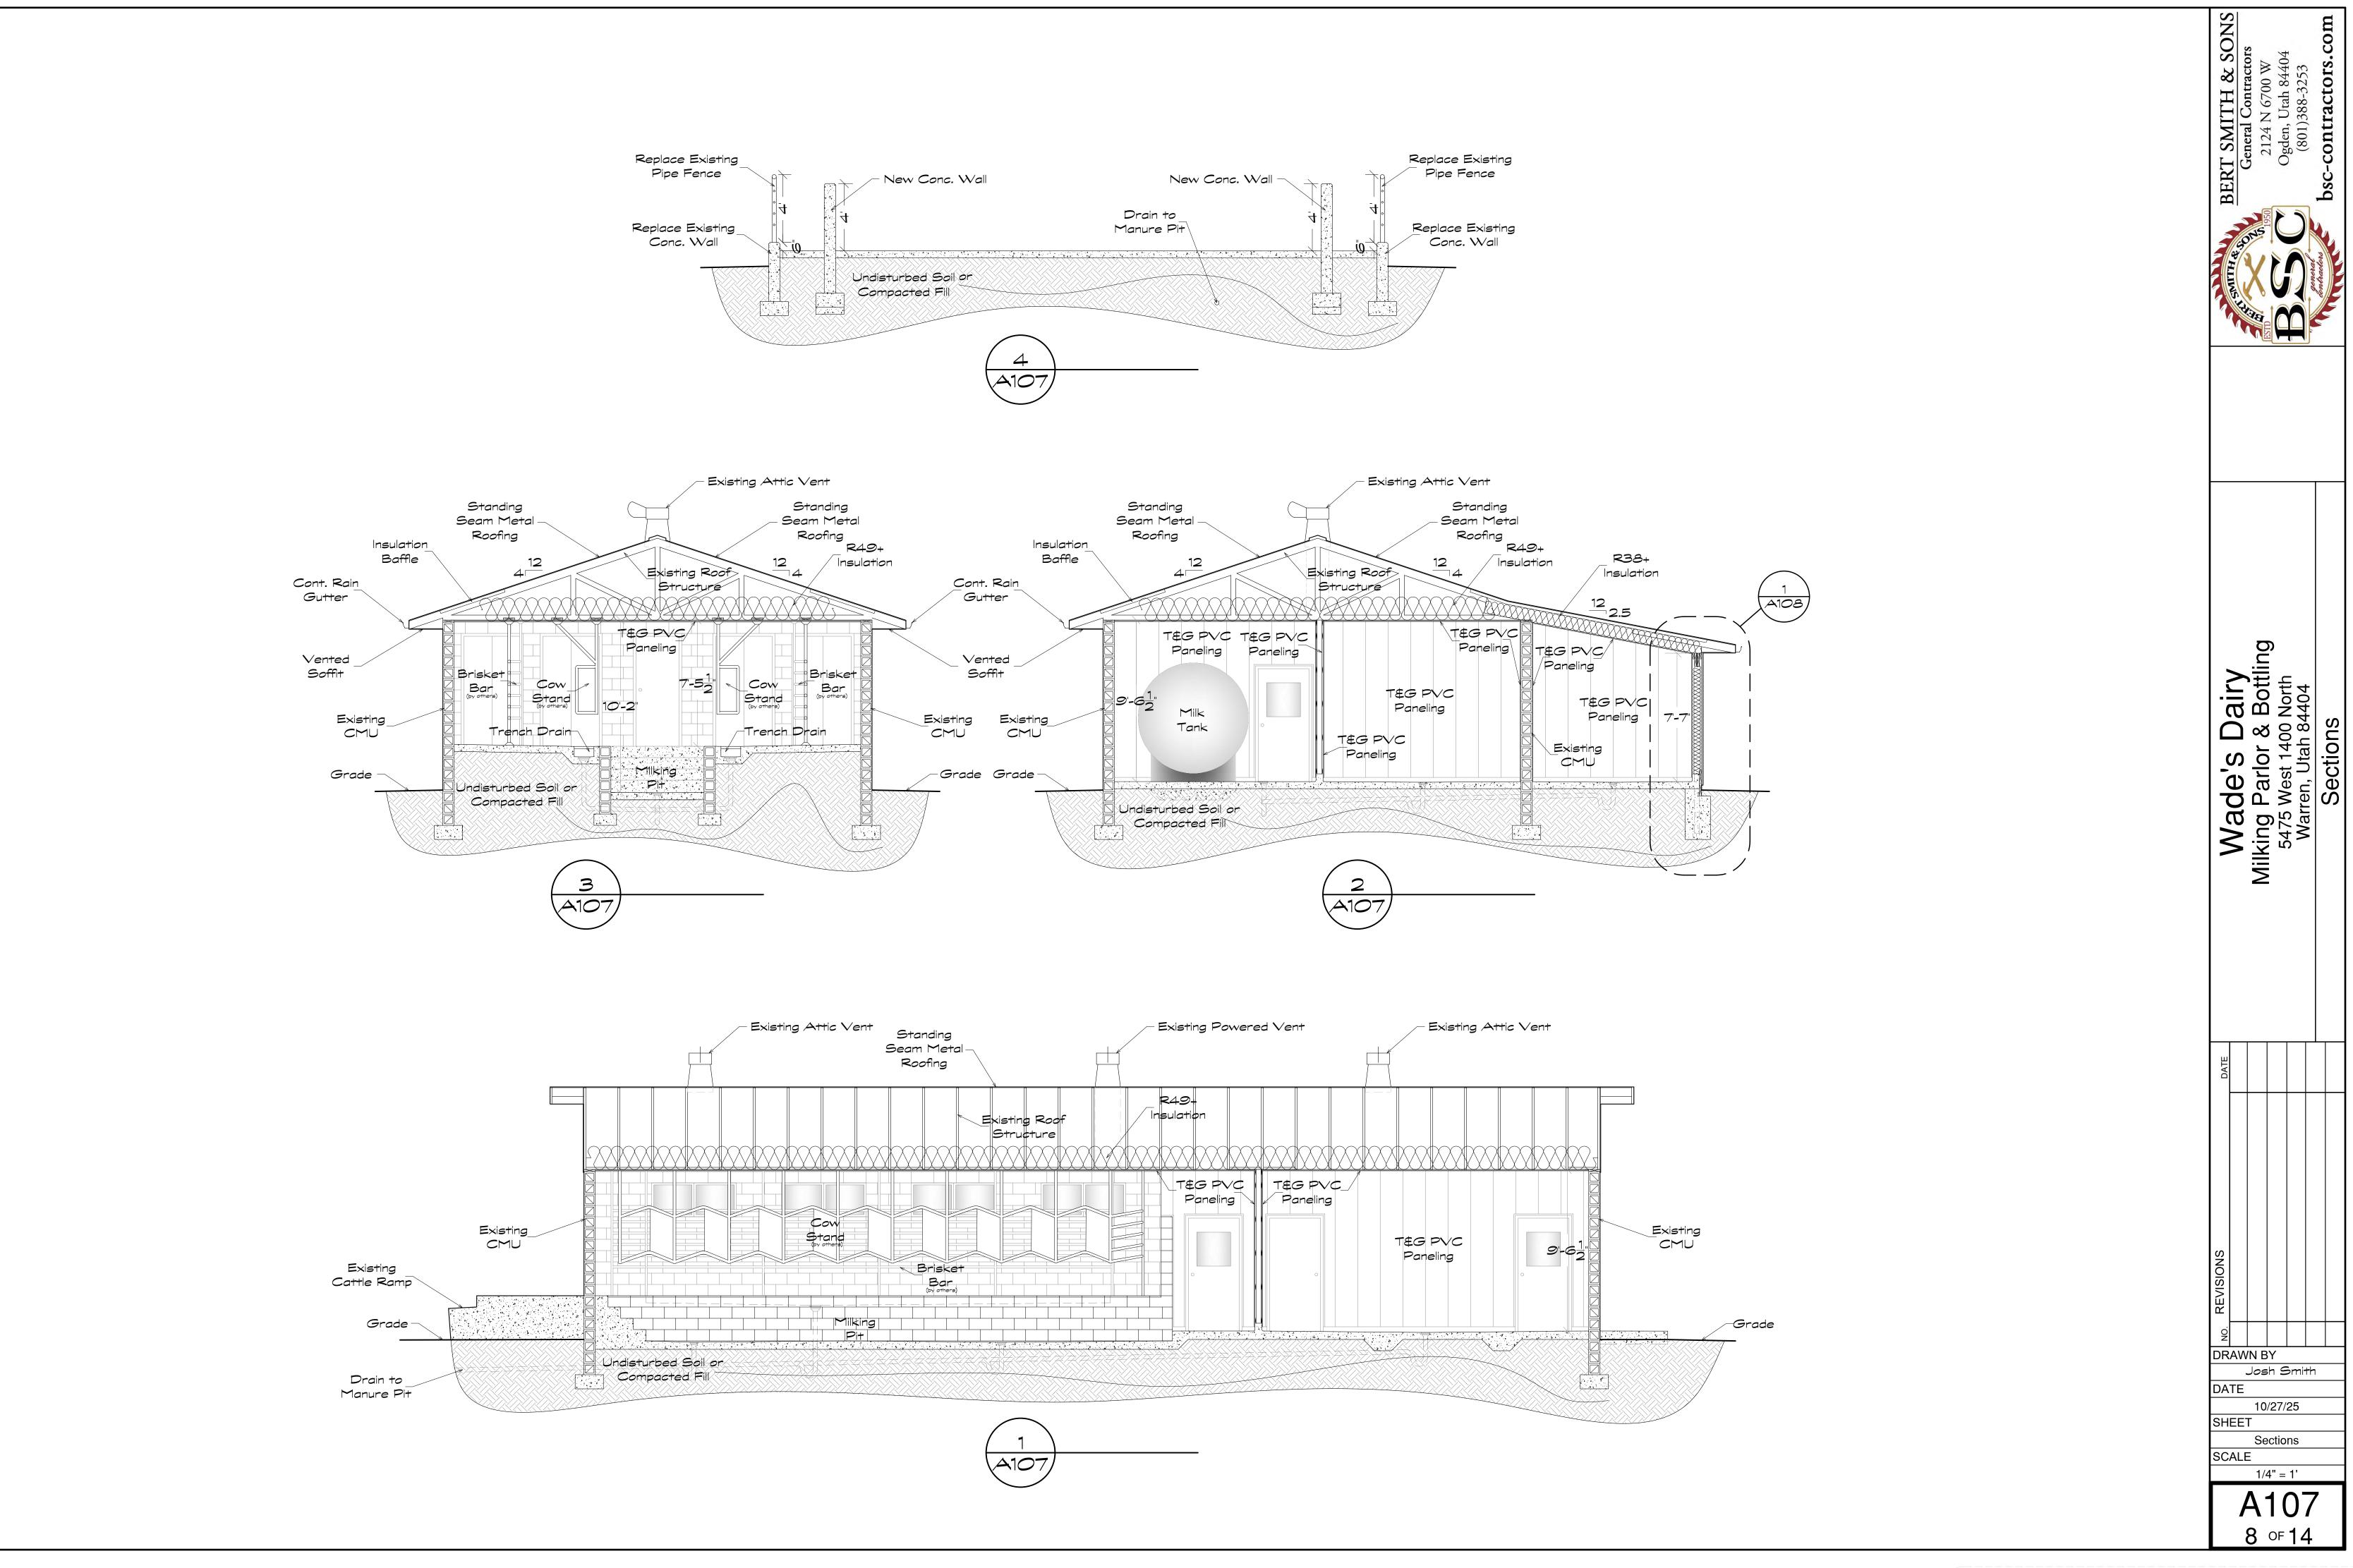

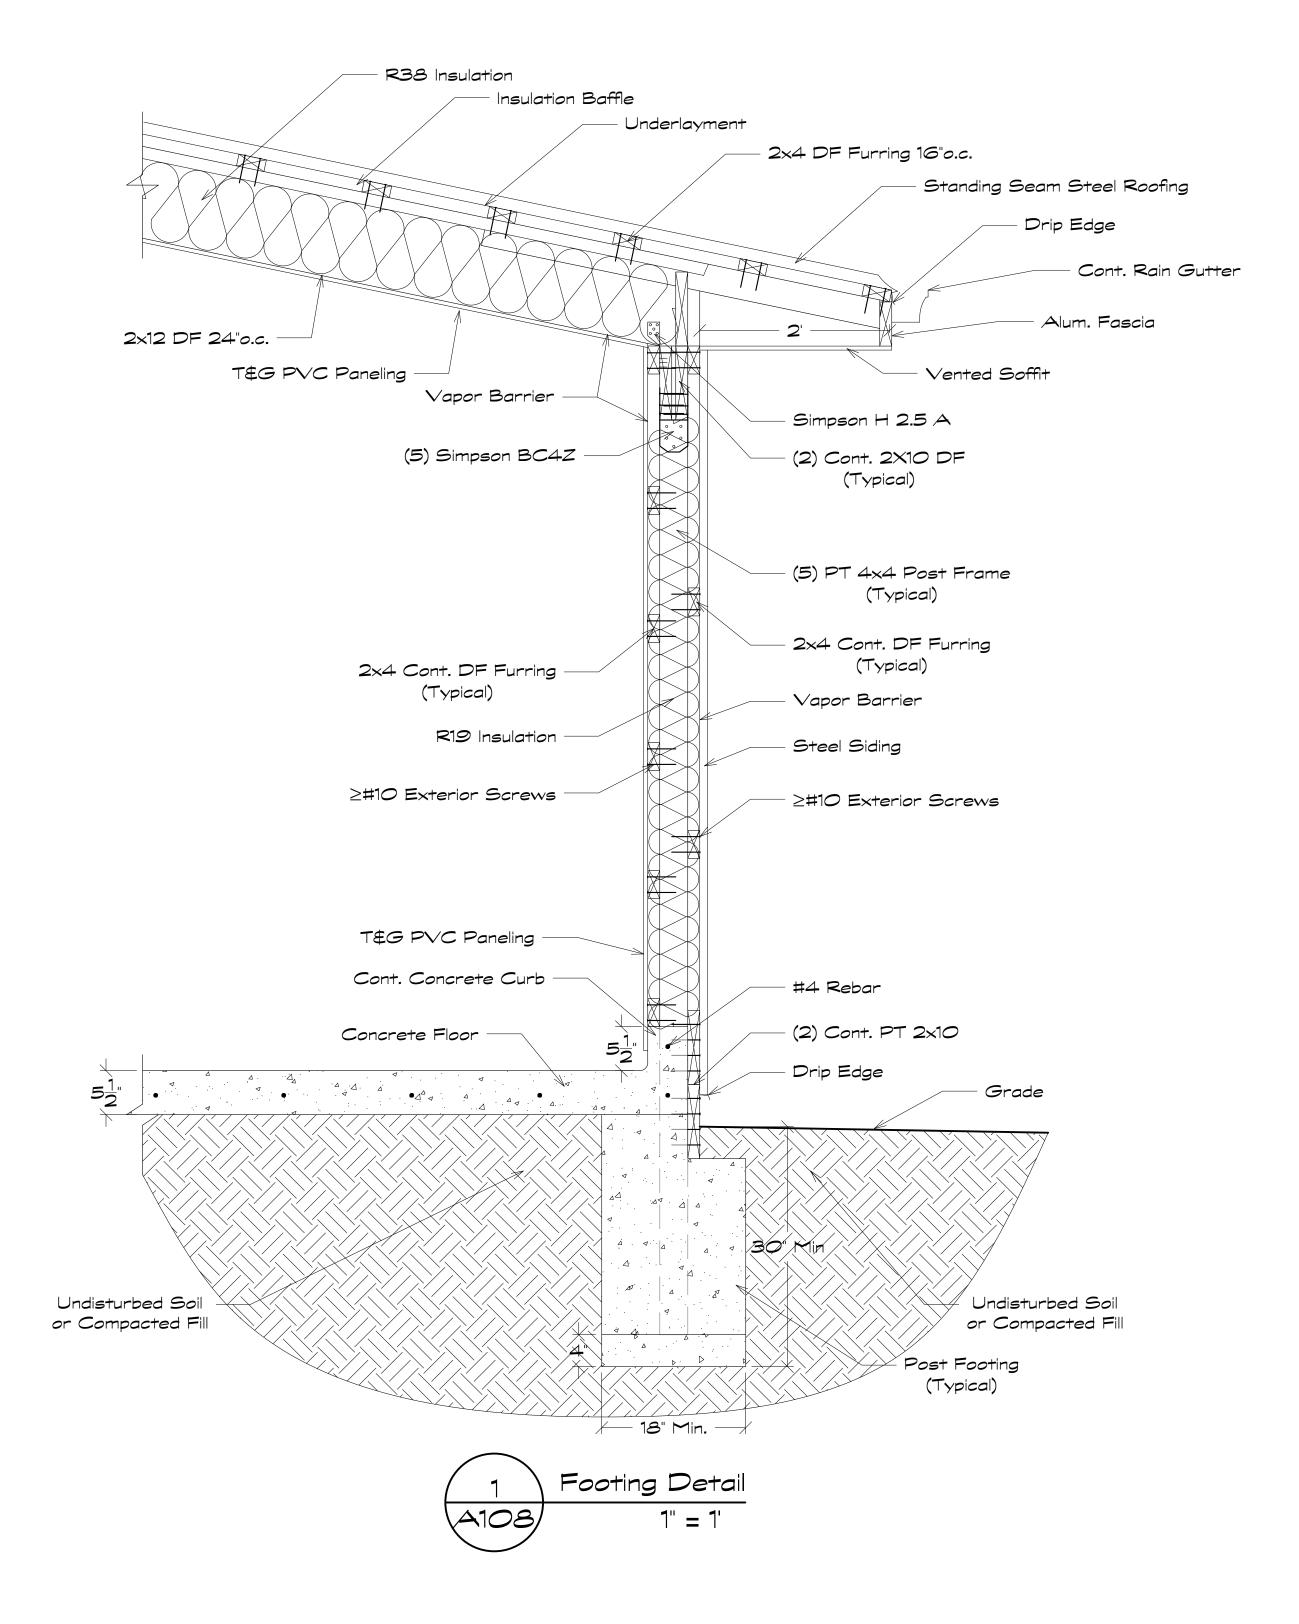

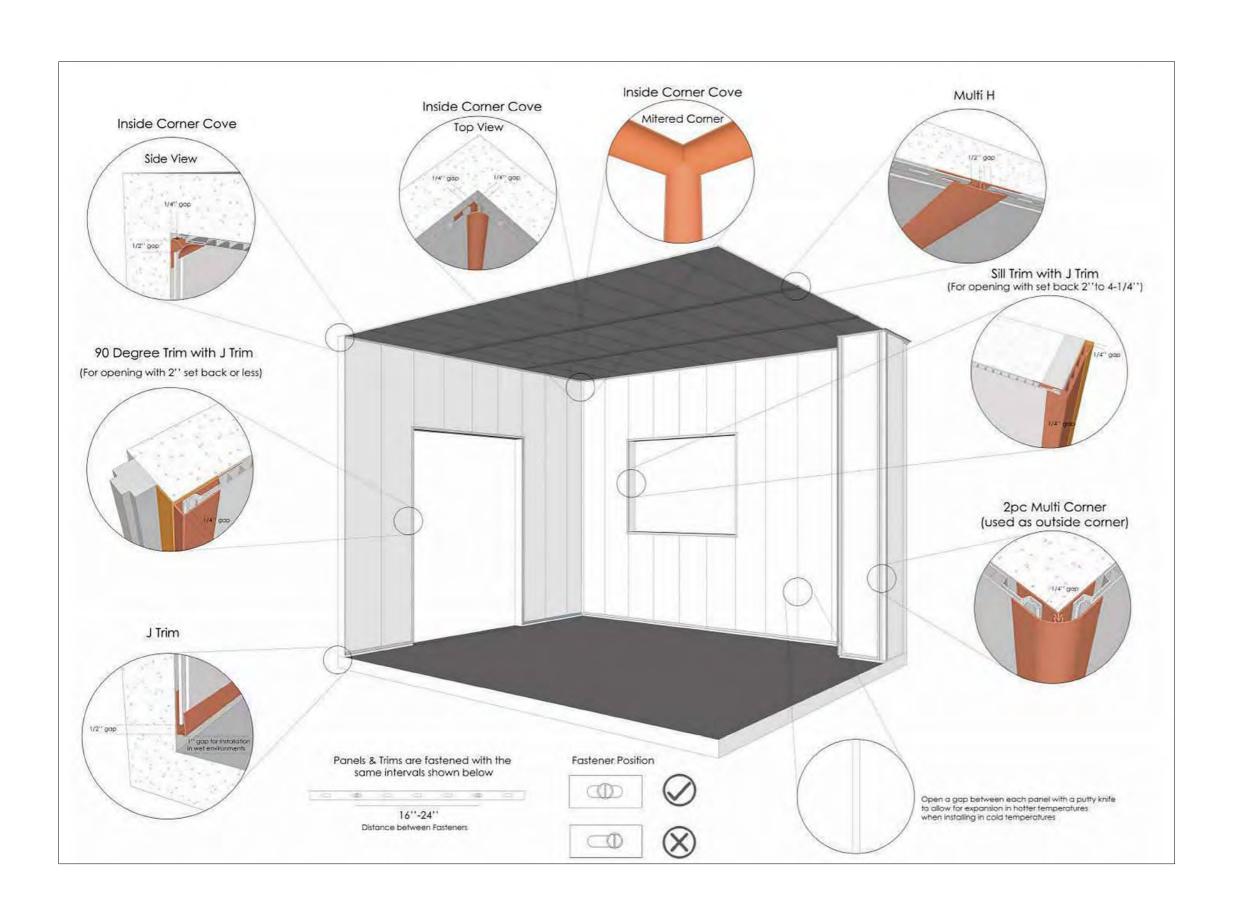




Dairy
Reserving
A00 North
In 84404 Wade's Da Milking Parlor & E 5475 West 1400 N Warren, Utah 84 DRAWN BY Josh Smith DATE 10/27/25 SHEET Details SCALE A108 9 of 14


PLUMBING SYMBOL LEGEND \ ABBREVIATIONS						
	FLOOR DRAIN	<del></del>	RISE IN PIPE		CHECK VALVE	
O FCO	FLOOR CLEAN OUT	+	ELBOW IN PIPE	<b>\$</b>	BALANCE VALVE	
	WALL CLEAN OUT	+++	TEE IN PIPE	VTR	VENT THROUGH ROOF	
	DOMESTIC COLD WATER (DCW)	<u></u> —√√—	GAS SHUTOFF VALVE	□ WHA	WATER HAMMER ARRESTOR	
ļi	DOMESTIC HOT WATER (DHW)	<b>-</b> \$	GAS PRESSURE REGULATOR	-A.D.	ACCESS DOOR	
	GAS LINE	4QF	BALL VALVE	A.F.F.	ABOVE FINISHED FLOOR	
	WASTE (W)		PIPE CAP	WH	WALL HYDRANT	
]	VENT (V)	₩C+	VALVE IN DROP	HB	HOSE BIBB	
<del></del>	DROP IN PIPE		UNION	M	MIXING VALVE	

PLUMBING FIXTURE SCHEDULE							
SYMBOL	DESCRIPTION	COLD	НОТ	TRAP	WASTE	VENT	REMARKS
P-1	Hand Sink, Wall mounted w/faucet	1/2"	1/2"	1-1/2"	2"	2"	Stubbed for future restroom
P-2	Water Closet	1"		N.	3"	2"	Stubbed for future septic system
P-3	Countertop Sink, w/faucet	1/2"	1/2"	[1-1/2" <sub></sub>	2"	2"	F.
P-4	Hand Sink, Wall mounted w/faucet	1/2"	1/2"	1-1/2"	2"	2"	3
	Floor Drain, 6" diameter grate				2"-4"	2	= E0
	Trench Drain, 14" grate			4"	4"		, is
	- 	1		û	S ≅*	1	ė.

#### GENERAL FIXTURE NOTES:

- 1. THE PLUMBING CONTRACTOR SHALL VERIFY THE REQUIREMENTS OF ALL PLUMBING EQUIPMENT AND THE RELATED ROUGH IN LOCATIONS WITH THE MECHANICAL AND
- ARCHITECTURAL PLANS AND SPECIFICATIONS, PROVIDE ALL ACCESSORIES AND OPTIONS REQUIRED TO PROVIDE THE OWNER A COMPLETELY FUNCTIONAL PLUMBING SYSTEM. 2. ALL WALL HUNG PLUMBING FIXTURES SHALL BE SUPPORTED BY FLOOR MOUNTED CARRIERS (WADE, SMITH, JOSAM, MIFAB, OR WATTS) CARRIERS SHALL BE CONSTRUCTED UTILIZ-ING ALL METAL COMPONENTS WITH SUPPORT FEET SECURELY ANCHORED TO FLOOR STRUCTURE. FIXTURE ARMS SHALL SUPPORT FIXTURE INDEPENDENT FROM WALL STRUCTURE.
- 3. EACH INDIMDUAL FIXTURE SUPPLY SHALL BE PROVIDED WITH A CHROME-PLATED QUARTER TURN STOP VALVE BRASSCRAFT MODEL KTCR\_ OR ENGINEER APPROVED EQUAL.
  4. FIXTURES AND ACCESSORIES SHALL BE AS SCHEDULED. EACH ITEM SHALL BE COMPLETE WITH CHROME-PLATED BRASS TRIM.
  5. ADA COMPLIANT FIXTURES SHALL BE INSTALLED WITH PRE-FORMED INSULATION AND PROTECTIVE COVERS ON P-TRAPS AND STOPS. COVERS TO BE MANUFACTURED BY BUCKAROOS OR TRUEBRO.
- 6. CAULK ALL FIXTURES TO THE WALL OR FLOOR WITH APPLICABLE SILICONE COMPOUND. UTILIZE MULTIPLE BEADS TO FILL GAPS AND FINISH TO SMOOTH, FILLETED EDGE. USE APPROPRIATE TOOLS TO PROVIDE PROFESSIONAL APPEARANCE.
- 7. ALL PLUMBING SHALL BE INSTALLED TO CONFORM TO THE LATEST ADOPTED EDITION OF THE INTERNATIONAL PLUMBING CODE INCLUDING LOCAL AMENDMENTS. CONSULT AUTHORITIES HAVING JURISDICTION.
- 8. ALL SINKS AND LAVATORIES WHERE HAND WASHING IS ANTICIPATED (FIXTURES P-2) SHALL BE PROTECTED WITH ASSE 1070 APPROVED TEMPERING VALVES PER DETAIL 7/P-000.

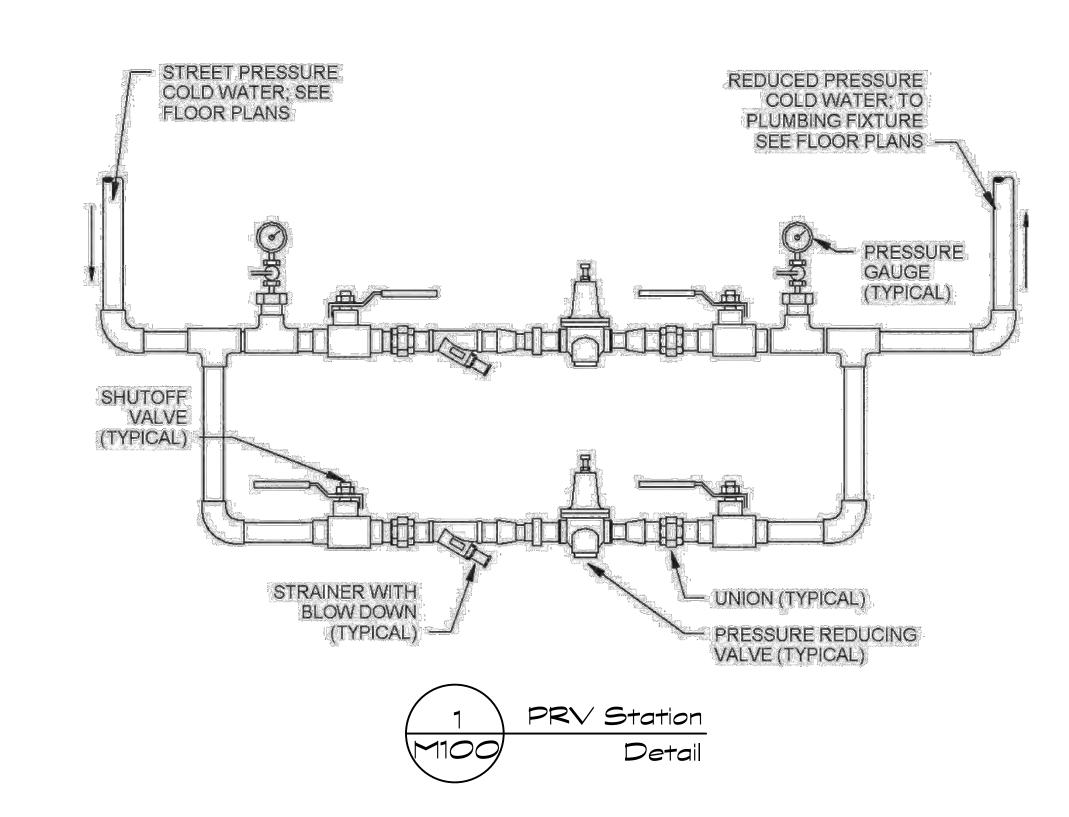

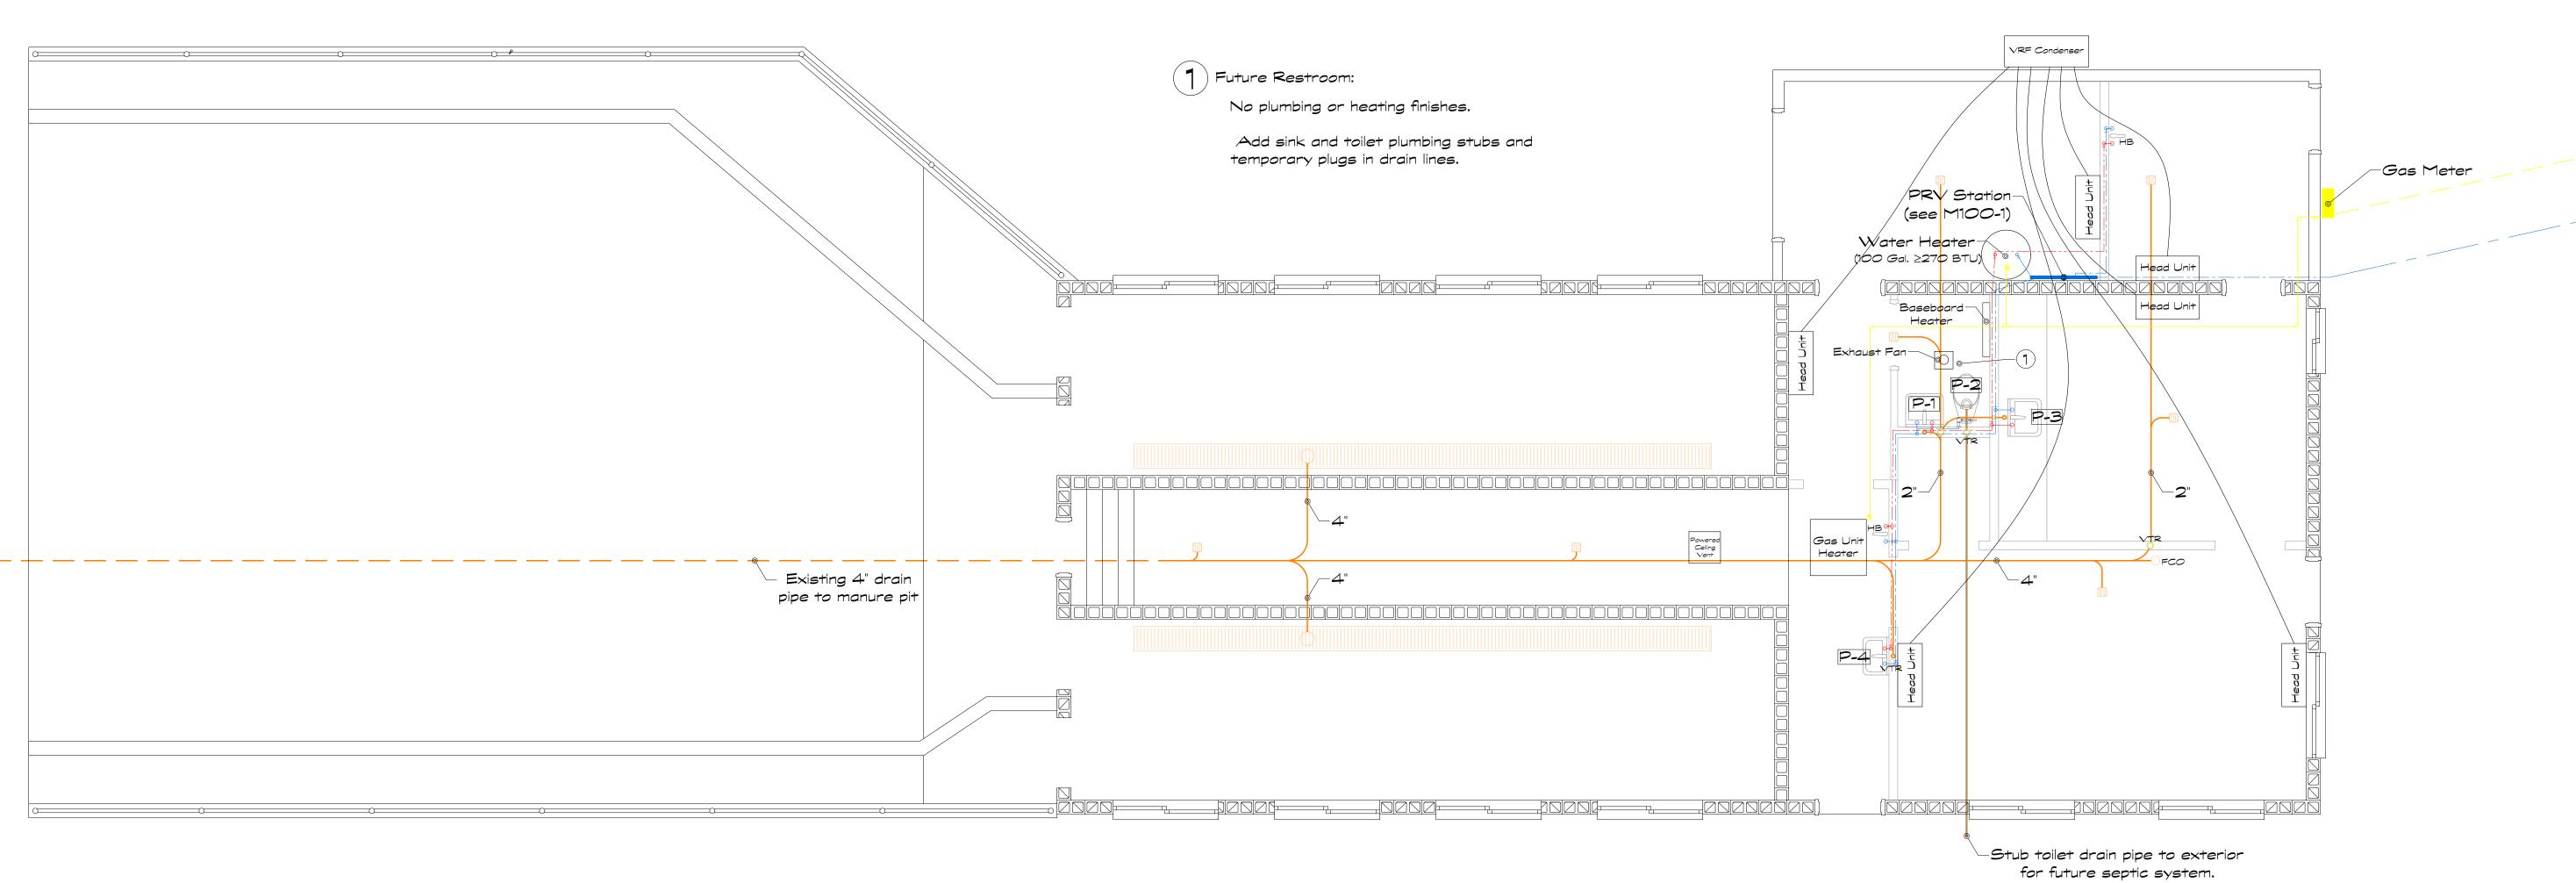

BERT SMITH & SONS General Contractors

ASTM B31.1 Piping

<u>DESCRIPTION OF PROJECT</u>: The mechanical work described in these mechanical specifications is for a project located in Ogden, Utah. Design weather conditions are: 95° db, 62° wb, and winter 8°F. Altitude readings, unless otherwise noted, are for an elevation of 4,450 feet above sea level. Make adjustment to manufacturer's performance data as needed.

CODES AND PERMITS, AUTHORITIES HAVING JURISDICTION:
2015 International Mechanical Code - (with Utah amendments)
2015 International Building Code - (with Utah amendments)
2015 International Plumbing Code - (with Utah amendments)
2015 International Energy Conservation Code - (with Utah amendments)
SMACNA Duct Design Standards
Locally enforced NFPA Codes
Local Fuel Utility Regulations
Local Power Utility Regulations
American Gas Association

<u>DEFINITION OF PLANS AND SPECIFICATIONS</u>: The mechanical drawings at reduced scale show the general arrangement of piping, ductwork, equipment, etc., and shall be followed as closely as the actual building construction and the work of other trades will permit. The architectural and structural drawings shall be considered as part of the work insofar as these drawings furnish the Contractor with information relating to design and construction of the building. Architectural drawings shall take precedence over mechanical drawings. Request clarification and participate in resolution in the event of conflict.

- Because of the small scale of the mechanical drawings, it is not possible to indicate all offsets, fittings and accessories which may be required. Investigate the structural and finish conditions affecting the work and arrange the work accordingly, providing such extensions, fittings, valves and accessories to meet the conditions as may be required. Some small scale work is not shown such as control conduit and piping, incidental piping, specialties. Provide as directed by note or specification
- B. Examine the actual construction site prior to bidding and obtain an understanding of the conditions under which the work will be performed. No allowances will be made for failure to make such examination.
- C. During construction, verify the dimensions governing the mechanical work at the building. No extra compensation shall be claimed or allowed because of differences between actual dimensions and those indicated on the drawings. Examine adjoining work on which mechanical work is dependent for perfect efficiency, and report any work of other trades which must be corrected. No waiver of responsibility for defective work shall be claimed nor allowed due to failure to report unfavorable conditions affecting the mechanical work.

<u>ALTERNATIVE CONSTRUCTION/SUBSTITUTION</u>: The contract documents outline a way in which the Owner may be delivered a functional and reliable facility. Drawings and specifications describe reasonable engineering practice for the Contractor to follow.

- A. Coordination between trades may result in periodic needs to adjust the installation from that indicated, but in no case shall the intended function be compromised.
- B. The Contractor may perceive some work methods which differ from those specified which could save time and effort. These may be presented to the Architect with a breakdown of possible cost savings for review. Implement only with authorization.
- C. Materials substitutions will generally be covered in a review process prior to bidding. After bidding, substitutions shall be proposed only on the basis of definitive cost accounting and implemented only with authorization.

#### QUALITY OF MATERIALS AND EQUIPMENT:

- A. All equipment and materials shall be new, and shall be the standard products of manufacturers regularly engaged in the production of plumbing, heating, ventilating and air conditioning equipment, and shall be the manufacturer's latest design. Specific equipment shown in schedules on drawings and specified herein is to be the basis for the Contractor's bid. Provisions for substitute equipment are outlined in the General Conditions. All materials shall be produced by manufacturing plants located in the United States of America.
- B. Furnish and install all major items of equipment specified in the equipment schedules on the drawings complete with all accessories normally supplied with catalog items listed, and all other accessories necessary for a complete and satisfactory installation.

MANUFACTURER'S DIRECTIONS: Install all equipment in strict accordance with directions and recommendations furnished by the manufacturer. Where such directions are in conflict with the plans and specifications, report such conflicts to the Architect who shall direct adjustments as deemed necessary and desirable.

#### VALVES:

#### DOMESTIC COLD WATER:

- A. Ball Valves: Copper piping, 2-1/2" and Smaller: 475 psig WOG @ 250°F, bronze construction, soldered ends for 3/4" and smaller, threaded ends for 1" and larger, glass Reinforced PolyTetraFlouroEthylene (RPTFE) seat providing bubbletight leakage performance at 100 psig air pressure under water, full port stainless steel ball. Operate with flow in either direction. Suitable for throttling and tight shut-off. Lever or tee handle as required.
  - Manufacturers & Models: Provide ball valves from one of the manufacturers and model numbers listed below.
  - (1) Apollo 77-140
  - (2) Watts FBV-SS (up to 2")
  - (3) Nibco T-580-70-66 (up to 1")(4) Crane/Stockham 285-BR-R-66
- INSULATION:

WATER PIPING (domestic cold water, 1" thickness required.)

- A. Preformed Fiberglass Piping Insulation: ASTM C 547. (Class 1 for use to 450°F (230°C); Class 2 for use to 650°F (345°C); Class 3 for use to 1200°F (650°C).

  DUCTWORK (1-1/2" thickness for all non-acoustically lined ductwork):
- Flexible Fiberglass Ductwork Insulation: ASTM C 553, Type 1 resilient, flexible; Class B-1 0.65 lbs/ft³; Class B-2 0.75 lbs/ft³; Class B-3 1.0 lbs/ft³; Class B-4 1.5 lbs/ft³; Class B-5 2.0 lbs/ft³; Class B-6 3.0 lbs/ft³; Type II flexible; Class F-1 4.5 lbs/ft³; Type III semirigid; Class F-2 4.5 lbs/ft³.

#### DOMESTIC WATER PIPING:

- A. Domestic Water Pipe:
  - 1. Pipe Sizes 4" and Smaller: Copper tubing. Conform to ASTM B88, Type L, hard temper, copper tube; ASME B16.22 streamlined pattern wrought-copper fittings, with soldered joints using 95-5 tin antimony solder or non-lead bearing solders such as "Silvabrite."

#### WASTE, DRAIN AND VENT PIPING:

- A. Sanitary Soil Drain, Waste and Vent Piping:
  - Piping and Fittings: Schedule 40 PVC pipe and fittings conforming to the requirements of ASTM D 2665. Pipe and fittings shall be produced domestically as supplied by Spears, or Charlotte Pipe and Fittings.

<u>EQUIPMENT AND PLUMBING FIXTURES</u>: Per manufacturer and model numbers indicated on mechanical and plumbing schedules.

#### **NATURAL GAS PIPING:**

- A. Building Distribution Piping:
- 1. Pipe Size 2" and Smaller: Black steel pipe; Schedule 40; malleable-iron threaded fittings (exposed), welded fittings and joints (concealed).
- 1. Gas Cocks 2" and Smaller: 150 psi non-shock WOG, bronze straightway cock, flat or square head, threaded ends.
  - 2. Manufacturer: Subject to compliance with requirements, provide gas cocks of one of the
    - following:
      a. DeZurik Corp.
    - b. Jenkins Bros.
    - Lukenheimer Co.
    - d. NIBCO, Inc.e. Powell (The Wm.) Co.
    - f. Rockwell International; Flow Control Div.
    - g. Stockham Valves and Fittings.
  - h. Walworth Co.
    Pressure Regulating Valves:
    - General: Provide single stage, steel jacketed, corrosion- resistant gas pressure regulators; with atmospheric vent, elevation compensator; with threaded ends for 2" and smaller, flanged ends for 2-1/2" and larger; for inlet and outlet gas pressures, specific gravity, and volume flow indicated.

#### DUCTWORK - GENERAL:

- A. Standards: All duct fabrications shall comply with standards and techniques detailed by SMACNA "Duct Construction Manuals" for the appropriate pressure class, with the ASHRAE Handbook, 1988 edition, Chapter 1, Duct Construction, and with the contract drawing details.
- Sheet Metal: Except as otherwise indicated, fabricate ductwork from galvanized sheet steel complying with ASTM A 527, lockforming quality, with G 90 zinc coating in accordance with ASTM A 525; mill phosphatized for exposed locations.

#### FITTINGS AND FABRICATION:

- A. Fittings: Fabricate duct fittings to match adjoining ducts, and to comply with duct requirements as applicable to fittings. Fabricate elbows utilizing inside and outside radiuses with a center-line radius equal to associated duct width; or where fully radiused elbows are not possible, fabricate elbows with an inside square and outside radius and include turning vanes in the first 1/3 of elbow. Maintain duct width throughout turn on inside square and outside radiused elbows. Limit angular tapers to 30° for contracting
- tapers and 20° for expanding tapers.

  B. Fabricate ductwork with accessories installed during fabrication to the greatest extent
- possible. Refer to Division-15 section "Duct Accessories' for accessory requirements.

  C. Fabricate ductwork with duct liner in each section of duct where indicated. Laminate

liner to internal surfaces of duct in accordance with instructions by manufacturers of lining and adhesive, and fasten with weld type fasteners.

D. Offset, transition, adapt ductwork to structural obstacles and work of other trades in a coordinated effort. Layout work to avoid conflict with piping, etc. With review of conditions, teardrop around conflicting piping, lights, etc., all at no added cost to the

#### LOW PRESSURE RECTANGULAR DUCTWORK:

- A. Rectangular ductwork for use on supply systems up to 2" maximum duct static pressure and 2000 fpm maximum duct velocity shall be constructed of galvanized steel using construction for nominal 3" SMACNA rated systems. Seal all transverse and longitudinal joints with water based duct sealer <u>NO EXCEPTIONS</u>.
- B. Use radiused elbows, or square inside radiused outside elbows with single thickness turning vanes in the first 1/3 where space restrictions prohibit fully radiused elbows. Use 45° high efficiency tapping takeoffs with separate downstream balance dampers.
- C. Duct dimensions are inside clear. Increase for acoustical lining.

#### MISCELLANEOUS DUCTWORK MATERIALS:

- A. General: Provide miscellaneous materials and products of types and sizes indicated and, where not otherwise indicated, provide type and size required to comply with ductwork system requirements including proper connection of ductwork and equipment.
- B. Runout Fittings: Runout fittings shall be used to make round to rectangular duct connections. Use 45° time and a half square to round fittings. Provide with locking quadrant dampers where balance is involved. Provide with insulation guard where insulated duct is involved.
- C. Duct Sealing Compound: Duct sealing compound shall be 3M brand number EC-750 or Duro-Dyne S-2. This material shall be used in making up duct joints or in water proofing, caulking plenums, etc.
- D. Acoustical Lining: Acoustical lining in ducts shall be 1" thick, 1-1/2 pound density, coated, flexible glass fiber type, set in adhesive and impaled on weld studs spaced not more than 12" on centers and secured with lock washers. Airstream surface faced with black coated matte. Acoustical lining shall completely line the ducts. Lining shall have a fire and smoke hazard rating not exceeding 20-50-50. Owens-Corning, Johns-Manville, Certainteed.
  - 1. All joints, edges and/or surface breaks in the coating of the acoustical lining shall be pointed up to a smooth surface with adhesive.
- E. Duct Liner Adhesive: Comply with ASTM C 916 "Specifications for Adhesives and Duct Thermal Insulation".
- F. Duct Liner Fasteners: Comply with SMACNA HVAC Duct Construction Standards, Article S2.11.
- G. Ductwork Support Materials: Except as otherwise indicated, provide hot-dipped galvanized steel fasteners, anchors, rods, straps, trim and angles for support of ductwork.

SNOISING SMITH

DRAWN BY

Josh Smith

DATE

10/27/25

SHEET

Mechanical Notes

SCALE

11 of 14

M101


BERT SMITH & SC General Contractors 2124 N 6700 W Ogden, Utah 84404

airy Bottling North 14404 Notes

Wed Med

**□** ∞ 8 ∞

e's arlor

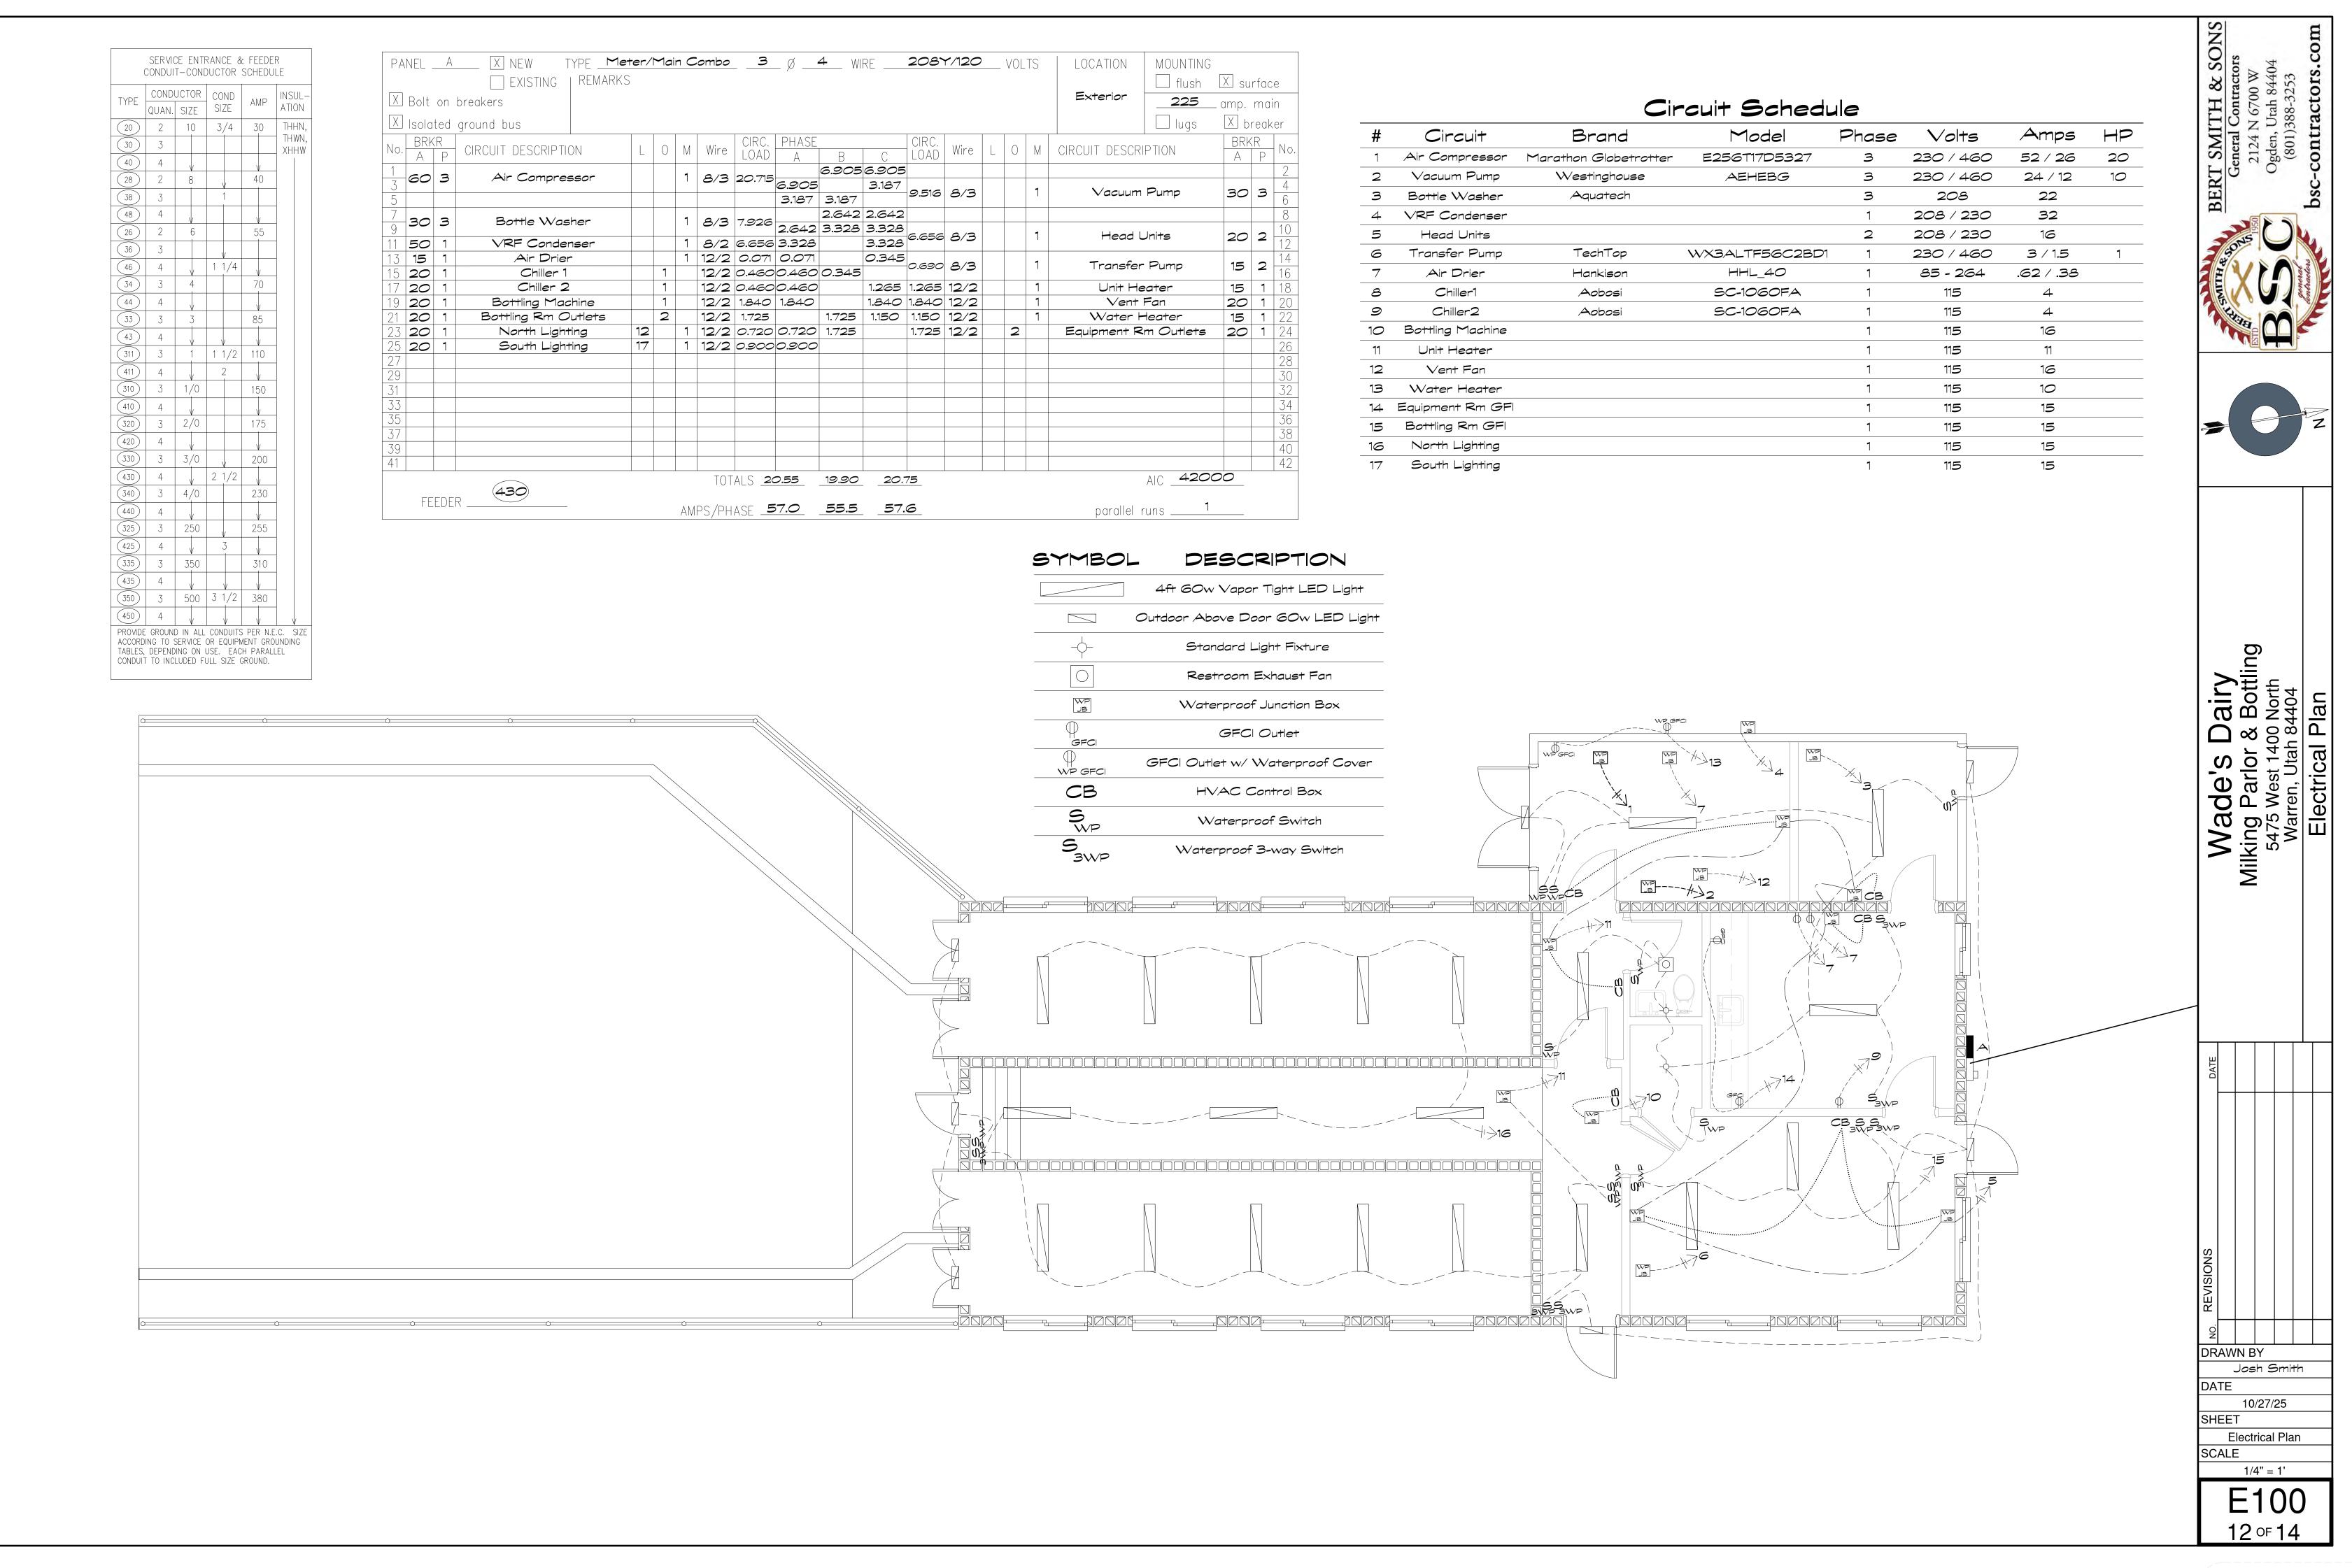

22. Conduit bodies

23. Bushings

24. Locknuts

BY. Verify all electrical loads (voltage, phase, full load amperes, number and point of connections, minimum circuit ampacity,

etc.) for equipment furnished under other Divisions of this specification, by reviewing respective shop drawings furnished

include the following: 1) A statement declaring the equipment proposed is equal to that specified by having the same

physical characteristics and dimensions and meet the drawings layout and structural conditions as well as load requirements;

13 of 14

DA. Where dedicated equipment is connected by cord and plug, provide a single receptable as required by code.

DB. Protection of wall plates and receptocles: At time of substantial completion, replace those items which have been

damaged, including those stained, burned and scored. DC. Grounding: Provide electrically continuous, tight grounding connections for wiring devices, unless otherwise indicated. DD. Testing: Prior to energizing circuitry, check wiring devices for electrical continuity and proper polarity connections. After energizing circuitry, test wiring devices to demonstrate compliance with requirements END OF SECTION 26 0140 SECTION 26 0160 - PANELBOARDS PART 1 — GENERAL 1.1 RELATED DOCUMENTS A Drawings and general provisions of Contract, including General and Supplementary Conditions and Division-1 Specification sections, apply to work of this section. B. This section is a Division—26 Basic Materials and Methods section, and is part of each Division—26 section making reference to panelboards specified herein. 1.2 DESCRIPTION OF WORK C. Extent of panelboard and enclosure work, is indicated by drawings and schedules. D. Types of panelboards and enclosures in this section include lighting and appliance panelboards, and power distribution 1.3 QUALITY ASSURANCE E. Provide units which have been UL listed and labeled. Comply with NEC as applicable to installation of panelboards, cabinets, and cutout boxes. Comply with NEC pertaining to installation of wiring and equipment in hazardous locations. Comply with NEMA stds. Pub No. 250. "Enclosures for Electrical Equipment (1000 volt maximum)". Pub No. 1. "Instructions for Safe Installation, Operation and Maintenance of Panelboards Rated 600 Volts or Less". F. Product Data: Submit manufacturer data including specifications, installation instructions and general recommendations, for each type of panelboard required. G. Shop Drawings: Submit dimensioned drawings of panelboards and enclosures showing accurately scaled layouts of enclosures and required individual panelboard devices, including but not necessarily limited to, circuit breakers, fusible switches, fuses, ground-fault circuit interrupters, and accessories. Panel dimensions shown on the drawings are one manufacturer's dimensions. Panel dimensions submitted by other manufacturers shall not exceed the panel dimensions shown on the PART 2 - PRODUCTS H. Acceptable Manufacturers: Subject to compliance with requirements, provide one of the following: General Electric Company Square D Company 3. Outler Hammer I. Panel sizes shown on drawings are for Square D panels. If other panels are substituted, the contractor shall verify proper dearances per N.E.C. Unless otherwise noted, main and distribution panels shall be a minimum 36" wide. J. Prior to submittals of shop drawings the panel board manufacturers representative shall make a field visit to verify that existing panels have available space for the new breakers called for on the drawings and that the proper frame breakers will be supplied. K. Panelboards: General: Except as otherwise indicated, provide panelboards, enclosures and ancillary components, of types, sizes, and ratings indicated. Equip with number of unit panelboard devices as required for complete installation. Fully equip "spaces" with hardware to receive breaker or switch of size indicated. L. Power Distribution Panelboards: Provide dead-front safety type power distribution panelboards as indicated, with switching and protective devices in quantities, ratings, types and with arrangement shown. Equip with copper bus bars, neutral bus and ground bus. Provide fusible or circuit breaker branch and main devices as indicated. M. Lighting and Appliance Panelboards: Provide dead-front safety type lighting and appliance panelboards as indicated, with switching and protective devices in quantities, ratings, types, and arrangement shown. Provide bolt-on thermal magnetic type branch breakers. Where multiple breakers are indicated provide with common trip handle. Equip with copper bus bars, neutral bus, and ground bus. N. All breakers in the main distribution panels shall have sufficient interrupting capacity to safely interrupt the available short circuit current from the transformer bank, as noted on the drawings. Panels and breakers are to be fully rated unless Manufacturer: All distribution and branch panels, breakers, and associated equipment shall be of the same manufacturer. P. Buss bracing shall be as required to handle fault current as shown on the drawings. Q. "Space" denotes a space fully equipped to receive a breaker of the type noted. R. Panelboard Enclosures: Provide galvanized sheet steel cabinet type enclosures, in sizes and NEMA types as indicated, code-gage minimum 16-gage thickness. Provide fronts with adjustable indicating trim clamps, and doors with flush locks and keys, all panelboard enclosures keyed dlike, with concealed door hinges and door swings as indicated. Equip with interior circuit-directory frame, and card with clear plastic covering. Provide baked gray enamel finish over a rust inhibitor. Provide enclosures fabricated by same manufacturer as overcurrent devices contained therein. Bolt engraved Formica labels indicating panel name and voltage on the interior and exterior of panelboards S. Finish: Coat interior and exterior of surface with manufacturer's standard color; baked on enamel finish. Identification: Provide 1/16" thick black Formica labels with 1/4" high white lettering on the interior of each panelboard; include panelboard name and voltage. Provide red Formica labels on emergency system panels. PART 3 - EXECUTION 3.1 INSTALLATION OF PANELBOARDS sharp metal edges or corners. X. Mounting: Provide 4" high concrete curb under floor standing distribution panelboards. enclosure, and secure with suitable nylon ties. Z. Branch panels shall generally be installed with the top of the panel at 6 ft. above floor. not architectural numbers used on drawings. Identify individual lighting circuits and individual receptacle circuits by room served. Include room number with equipment circuit designations. All directories to be typewritten. AB. Provide identification of disconnecting means as required by NEC 225-37 or 230-2. AC. All subpanels shall be labeled to identify the main panel that supplies the feeder circuit. AD. All feeder circuit breakers shall be labeled to identify the location of the subpanel or equipment supplied. engraved plastic identification label, with black background and white lettering, to panel cover. shop drawings before the installation of service and feeder conduits. END OF SECTION 26 0160 SECTION 26 0170 - MOTOR & CIRCUIT DISCONNECTS Part 1 — Ceneral 1.1 RELATED DOCUMENTS

V. General: Install panelboards and enclosure where indicated, in accordance with manufacturer's written instructions, applicable requirements of NEC and NECA's "Standard of Installation", in compliance with recognized industry practices to ensure W. Panelboard Makeup: In making up a panel, the conductors shall be neatly formed therein. Wires shall be protected from

Y. Coordinate installation of panelboards and enclosures with cable and raceway installation work. Anchor enclosures firmly to walls and structural surfaces, ensuring they are permanently and mechanically secure. Arrange conductors neatly within AA. Fill out panelboard's circuit directory card upon completion of installation work. Utilize actual final building room numbers,

AE. Where more than one voltage system is used in a building identify color coding at each panel per NEC 210-4D. Fasten

AF. Electrical Contractor shall verify the fit and required N.E.C. dearances of the equipment in the main electrical room(s) with

AG. Drawings and general provisions of Contract, including General and Supplementary Conditions and Division—1 Specification sections, apply to work of this section.

AH. This section is a Division-26 Basic Materials and Methods section, and is part of each Division-26 section making reference

to motor and circuit disconnect switches specified herein. 1.2 DESCRIPTION OF WORK Al. Extent of motor and circuit disconnect switch work is indicated by drawings and schedules. Work includes complete installation and electrical connections.

AJ. Provide motor and circuit disconnect switches which have been UL listed and labeled. Comply with applicable requirements of NEMA Stds Pub. No. KS 1, and NEC. 1.4 SUBMITTALS

AK. Product Data: Submit manufacturer's data including specifications, installation instructions and general recommendations, for each type of motor and circuit disconnect switch required. AL. Shop Drawings: Submit dimensioned drawings of electrical motor and circuit disconnect switches which have rating of 100

amperes and larger. PART 2 - PRODUCTS AM. Acceptable Manufacturers: Subject to compliance with requirements, provide products of one of the following (for each type

6. General Electric Co. Square D Company 8. Outler Hammer AQ. Manufacturer subject to compliance with requirements, provide fuses of the following manufacturer, no substitution:

10. Littelfuse 11. Fdison AR. Enclosures: Enclosures shall be NEMA type 1 or, where required as weatherproof, NEMA Type 3R. AS. Fabricated Switches: General: Provide disconnect and safety switches sized as required for the load served and as

indicated herein fused unless noted otherwise. Provide: 12. Heavy duty switches on 240 Volt rated circuits. 13. HP rated switches on all motor circuits. AT. Heavy Duty Switches: Provide heavy-duty type, sheet-steel enclosed switches, fusible as indicated of types, sizes and electrical characteristics indicated; rated 240 (or 600) volts, 60 hertz; incorporating spring assisted, quick-make,

quick-break mechanisms. Provide single phase or three phase and with solid neutral as required by application. Equip with operating handle which is capable of being padlocked in OFF position. Provide NEMA 1 or NEMA 3R as required by application, unless noted. Provide fusible switches with Class R rejection fuse dip kits. AU. Fuses: Provide fuses for switches, as required of classes, types and ratings needed to fulfill electrical requirements for

service indicated. Fuses shall be Bussman low peak sized not to exceed 125% of motor full load amperes for motors with a 1.15 service factor and sized not to exceed 115% of motor full load amperes for all other motors. Provide spare fuses amounting to one spare fuse for each 10 installed but not less than three of any one type and size. Provide Buss SAM fuse covers for each fuse. PART 3 — EXECUTION

3.1 INSTALLATION OF MOTOR AND CIRCUIT DISCONNECT SWITCHES

1.3 QUALITY ASSURANCE

Bussmann

AV. Install motor and circuit disconnect switches where indicated, complying with manufacturer's written instructions, applicable requirements of NEC, NEMA, and NECA's "Standard of Installation" and in accordance with recognized industry practices to

ensure that products fulfill requirements. AW. Coordinate motor circuit disconnect switch installation work with electrical raceway and cable work, as necessary for proper

AX. Install disconnect switches used with motor driven appliances, and motors and controllers within sight of controller position. AY. Provide identification of disconnecting means as required by NEC 225-37 or 230-2.

SECTION 26 0420 - SERVICE ENTRANCE Part 1 — General

1.1 RELATED DOCUMENTS

AZ. Drawings and general provisions of Contract, including General and Supplementary Conditions and Division—1 Specification sections, apply to work of this section. BA. Division—26 Basic Materials and Methods sections apply to work specified in this section.

1.2 DESCRIPTION OF WORK BB. Extent of service-entrance work is indicated by drawings and schedules. BC. Switchboards, panels, disconnects, transformers, etc., used for service-entrance equipment are specified in applicable Division-26 sections, and are included as work of this section.

BD. Consult local utility relative to all costs for line extensions, connections, etc., and include all costs for bringing service to the facility in base bid. Confirm location of point of service before bidding. BE. Provide labor and materials as required to accomplish power company metering in accordance with power company standards

and requirements. BF. Provide concrete pads or vaults of size and type required for service transformers including any utility required primary conduit stub outs. Verify location, size, openings, reinforcing requirements with local utility before beginning work. Comply with local utility clearance requirements. Location of pads shown on the drawings are approximate only.

1.3 QUALITY ASSURANCE BG. Comply with NEC and NEMA standards as applicable to construction and installation of service-entrance equipment and accessories. Provide service-entrance equipment and accessories which are UL-listed and labeled, and equipment marked, "Suitable for use as Service Equipment".

1.4 SUBMITTALS BH. Product Data: Submit manufacturer's data on service-entrance equipment and accessories.

Bl. Shop Drawings: Submit dimensioned layouts of service-entrance equipment and spatial relationships to proximate equipment. BJ. Maintenance Stock, Fuses: For types and ratings required, furnish additional fuse, amounting to one unit for every 2 installed units, but not less than one unit of each. PART 2 - PRODUCTS

2.1 SERVICE - ENTRANCE EQUIPMENT BK. General: Provide service-entrance equipment and accessories of types, sizes, ratings and electrical characteristics indicated, which comply with manufacturer's standard materials, design and construction in accordance with published product information, and as required for complete installation, and as herein specified. Each service disconnect shall be marked to identify it as a service disconnecting means. Where more than one service disconnect is used, all disconnects shall be labeled as required by NEC.

2.2 OVERCURRENT PROTECTIVE DEVICES BL. General: Provide overcurrent protective devices as indicated on drawings.

BM. Meter Sockets and Current Transformer cabinets: Provide meter sockets and current transformer cabinets which comply with requirements of local utility company supplying electrical power to service-entrance equipment of building project. 2.3 RACEWAYS AND CONDUCTORS

BN. General: Provide raceways and conductors complying with applicable Division—26 Basic Materials and Methods sections. BO. Wall and Floor Seals: Provide wall and floor seals complying with Division—26 Basic Materials and Methods section

PART 3 - EXECUTION 3.1 INSTALLATION

BP. Provide and install an electric service to the facility as shown on the drawings and specified herein. The electrical contractor shall be responsible for any cost assessed by the serving utility to provide an electric service as shown on the plans and/or specified herein.

BQ. The service metering shall be as per the local power company or as specified herein. BR. Construction Lighting and Power shall be arranged for as specified under the General Conditions. BS. Before purchase of any service entrance equipment the contractor shall review with the power company the proposed service

as shown on the drawings and the probable date when the service connection from the power company will be needed. BT. Transformer Pad: The electrical contractor shall be responsible to confirm the transformer pad & specifications, and dearance from other equipment and structures with the serving power company before beginning installation.

BU. Installation of Service-entrance Equipment: Install service-entrance equipment as indicated, in accordance with equipment manufacturer's written instructions, and with recognized industry practices, to ensure that service-entrance equipment fulfills requirements. Comply with applicable installation requirements of NEC and NEMA standards.

BV. Coordinate with other work, including utility company wiring, as necessary to interface installation of service-entrance BW. Install all floor standing service equipment on 4" high concrete curb and bolt equipment to curb with 5/8" anchors at each

corner and at intervals not to exceed 48" along perimeter. Install wiring trench under floor standing equipment; 12" deep, and 4" smaller in length and width than equipment base. Install grounding bushings on conduits penetrating trench. BX. Grounding: Provide system and equipment grounding and bonding connections for service-entrance equipment and

conductors, as required. BY. Adjust and clean: Adjust operating mechanisms for free mechanical movement. BZ Touch-up scratched or marred enclosure surfaces to match original finishes.

CA. Provide a neutral from the service transformer to all main service disconnects including 3 phase service disconnects for motor circuits whether or not they are shown on the drawings. CB. Provide bonding bushings on all conduits.

CC. Field Quality Control: Upon completion of installation of service-entrance equipment and electrical circuitry, energize circuitry. and demonstrate capability and compliance with requirements. Where possible, correct malfunctioning units at site, then retest to demonstrate compliance; otherwise, remove and replace with new units, and proceed with retesting.

SECTION 26 0452 - GROUNDING

Part 1 — General

1.1 RELATED DOCUMENTS CD. Drawings and general provisions of Contract, including General and Supplementary Conditions and Division—1 Specification sections, apply to work of this section.

CE. Division—26 Basic Materials and Methods sections apply to work specified in this section. 1.2 DESCRIPTION OF WORK OF. Provide grounding as specified herein, and as indicated on drawings.

CG. Types of grounding in this section include the following: Underground metal water piping

16. Metal building frames 17. Grounding electrodes Grounding rods Service equipment

20. Endosures 21. Systems

22. Equipment 23. Other items indicated on drawings

CH. Requirements of this section apply to electrical grounding work specified elsewhere in these specifications. 1.3 QUALITY ASSURANCE

a. Comply with NEC as applicable to electrical grounding and ground fault protection systems. Comply with applicable ANSI and IEEE requirements. Provide products which have been UL listed and labeled. 1.4 SUBMITTALS

CJ. None required. PART 2 - PRODUCTS

> CK. Materials and Components: Ceneral: Except as otherwise indicated, provide each electrical grounding system as specified herein, and as shown on drawings, including but not necessarily limited to, cables/wires, connectors, terminals (solderless lugs), grounding rods/electrodes and plate electrodes, bonding jumper braid, and other items and accessories needed for

CL. Where Materials or Components are not otherwise indicated, comply with NEC, NEMA and established industry standards for applications indicated. CM. Electrical Grounding Conductors: Unless otherwise indicated, provide electrical grounding conductors for grounding connections

matching power supply wiring materials and sized according to NEC. CN. Ground Rods: Steel with copper welded exterior, 3/4" dia. x 10".

CO. Footing Ground: Install 20 ft. of #4 bare copper wire in footings and connect to footing rebar. PART 3 - EXECUTION

3.1 GENERAL CP. The electrical service entrance and conduit system throughout the project shall be grounded as required by N.E.C. Connect to all available electrodes per N.E.C. 250–50

CQ. All rotating equipment shall be grounded in compliance with the N.E.C. CR. All plastic conduit runs shall include a grounding conductor as per N.E.C. requirements. Conduit sizes shown are for steel conduit. If plastic conduit is used the contractor shall verify conduit size to accommodate the required grounding

CS. Provide full size ground in each conduit of parallel conduit systems per N.E.C. 250-122. CT. Separate neutrals shall be installed on all GFI breakers. 3.2 INSTALLATION OF GROUNDING SYSTEMS

CU. Install electrical grounding systems in accordance with manufacturer's written instructions and with recognized industry practices to ensure grounding devices comply with requirements. CV. Install braided type bonding jumpers with ground clamps on water meter piping to electrically bypass water meter. CW. Install clamp-on connectors only on thoroughly cleaned and metal contact surfaces, to ensure electrical conductivity and

CX. Provide grounding for the entire raceway, enclosure, equipment and device system in accordance with NEC. All non-metallic raceways shall include copper grounding conductor sized in accordance with NEC.

CY. Provide service entrance grounding by means of ground rods (quantity of two, driven exterior to building), by means of bonding to water main, by means of bonding to building structural steel, and by means of footing ground. Drive ground rods a minimum of 15 ft. apart. CZ. Provide grounding conductors for dimming systems in accordance with manufacturer's requirement.

DA. Install bonding bushings on all main service and feeder conduit terminations where metallic conduit connects to panels,

wireways, etc. DB. Provide an equipment grounding conductor bonded to the case of any dry type transformer on the primary side. Grounding conductor to connect from ground bus on panel supplying the transformer. Grounding of transformers and transformer

secondarys shall be per NEC 250-30. DC. Grounding electrode conductors shall be bonded to the exterior of the service equipment cabinet and interior through the grounding buss bonding strap. If metallic protection conduit is used over the grounding electrode conductor it shall be bonded to the grounding electrode at the point of entrance with a UL approved fitting. The conduit shall be continuous from the point of conductor entry to the service equipment cabinet where the conduit shall penetrate the cabinet and be secured with double lock nuts. The secondary conductor raceway between the transformers and the service equipment shall not be bonded to the transformer primary and secondary grounding system at the transformer and shall be electrically isolated from the transformer enclosures and ground system.

DD. Provide an equipment grounding conductor from the generator output to the transfer switch and on to the generator main panel. Bond to all equipment.

DE. See drawings for additional grounding requirements.

SECTION 26 0510 - INTERIOR AND EXTERIOR BUILDING LIGHTING

1.1 RELATED DOCUMENTS A. Drawings and general provisions of Contract, including General and Supplementary Conditions and Division—1 Specification

sections, apply to work of this section B. Division—26 Basic Materials and Methods sections apply to work specified in this section. 1.2 DESCRIPTION OF WORK

Extent of interior and exterior lighting fixture work is indicated by drawings and schedules.

D. Types of lighting fixtures in this section include the following:

1.3 QUALITY ASSURANCE

END OF SECTION 26 0452

Part 1 — General

E. Comply with NEC, NEMA and ANSI 132.1 as applicable to installation and construction of lighting fixtures. Comply with NEC 410-64C for all recessed incandescent light fixtures. Provide lighting fixtures which have been UL-listed and labeled.

F. CBM Labels: Provide fluorescent-lamp ballasts which comply with Certified Ballast Manufacturers Association standards and carry the CBM label. SUBMITTALS

G. Product Data: Submit manufacturer's data on interior and exterior building lighting fixtures.

H. Shop Drawings: Submit dimensioned drawings of lighting fixtures. Submit fixture shop drawings in booklet form with separate sheet for each fixture, assembled in luminaire "type" numerical order, with proposed fixture and accessories clearly indicated on each sheet PART 2 - PRODUCTS

2.2 INTERIOR AND EXTERIOR LIGHTING FIXTURES

General: Provide lighting fixtures, of sizes, types and ratings indicated complete with, but not necessarily limited to, housings, lamps, lamps holders, reflectors, ballasts, starters, and wiring. Label each fixture with manufacturer's name and catalog number. Provide all enclosed fixtures with positive latch mechanisms; spring tension dips not acceptable. Provide all exterior fixtures with damp or wet location label as required by application.

Where the light fixture schedule indicates "Color per Architect" this shall be interpreted as requiring a non-standard color. Support Requirements: Provide all pendant and stern hung fixtures with flexible ball joint hangers rated for seismic zone 3 at all points of support. Equip hooks used to hang fixtures with safety latches. Provide all detachable fixture parts, luminous ceiling accessories, louvers, diffusers, lenses, and reflectors with locking catches, screws, safety chain, or safety

L. Diffusers: Where plastic diffusers are specified, provide 100 percent virgin acrylic compound; minimum thickness, .125 inches. Provide a spare set of diffusers (acrylic and/or glass only) for each fixture type and one for each additional 10 fixtures of each type; not to exceed 10 spares for any single fixture type. PART 3 - EXECUTION

INSTALLATION OF LIGHTING FIXTURES:

V. Install lighting fixtures at locations and heights as indicated, in accordance with fixture manufacturer's written instructions, applicable requirements of NEC, NECA's "Standard of Installation", NEMA standards, and with recognized industry practices to ensure that lighting fixtures fulfill requirements.

W. Seismic bracing: Provide galvanized chain braces on all chain pendant hung light fixtures (pendant length greater than 12") to prevent swaying in any direction. On continuous row installations provide "4 direction" bracing every 16 feet.

X. All recessed light fixtures mounted in fire rated ceiling (See architectural drawings) shall have a fire rated cover installed over them per the ceiling manufacturers recommendation, and shall have ballasts approved for installation under such covers. Y. Coordinate with other work as appropriate to properly interface installation of lighting fixtures with other work. Consult architectural reflected ceiling plan for exact location of all lighting fixtures.

Z. Provide all necessary supports, brackets, and miscellaneous equipment for mounting of fixtures. Support all ceiling mounted fixtures from the building structure; independent of the ceiling system, unless noted. Support each recessed T-bar mount fixture (fluorescent incandescent, and/or HID) from the building structure with #10 ga. steel wire attached to each corner (in addition to supports normally provided for attachment to the ceiling system). Provide backing supports above (or behind) sheetrock, plaster and similar ceiling and wall materials. Support surface mounted ceiling fixtures from channel. Support ceiling mounted outlet boxes independent of the raceway system, and capable of supporting 200 pounds. See plans for additional details.

AA. Fixture support by toggle bolts through sheetrock is not acceptable. AB. Coordination Meetings: Meet with the General Contractor and the ceiling installer before submittal of shop drawings to coordinate each light fixture mounting condition with ceiling type and thickness. Coordinate fixture layout in each area. Adjust fixture mount as required by thickness of ceiling for proper fixture trim installation

AC. Meet with Mechanical: Meet with the mechanical installer prior to fabrication and installation of duct work. Coordinate depth and location of all recessed fixtures and duct work in all areas.

engineer will require all dusty or dirty fixtures and lenses to be cleaned for final construction review. AE. Protect installed fixtures from damage during remainder of construction period. Repair all nicks and scratches to

appearance of original finish. 3.2 FIELD QUALITY CONTROL

AF. Upon completion of installation of lighting fixtures, and after building circuitry has been energized, apply electrical energy to demonstrate capability and compliance with requirements. Where possible, correct malfunctioning units at site, then retest to demonstrate compliance; otherwise remove and replace with new units, and proceed with retesting.

AG. At the time of Substantial Completion, replace lamps in interior lighting fixtures which are observed to be noticeably dimmed after the Contractor's use and testing, as judged by Architect/Engineer. In addition, furnish stock or replacement lamps amounting to 15 percent (but not less than one lamp) of each type and size used. Deliver replacement stock as directed to Owner's storage space.

AH. Grounding: Provide tight equipment grounding connections for each lighting fixture.

Al. Meet with the General Contractor before the submittal of shop drawings to coordinate each light fixture mounting condition with ceiling type and thickness. Adjust fixture type or mount as required by ceiling type or thickness for proper installation. END OF SECTION 26 0510

SECTION 26 0740 - TELEPHONE AND COMPUTER (RACEWAYS)

supporting devices, and other sections, as applicable.

AP. Provide plywood terminal backboards, 4' x 8' x 3/4" unless noted otherwise.

PART 1 - GENERAL

1.1 RELATED DOCUMENTS AJ. Drawings and general provisions of Contract, including General and Supplementary Conditions and Division—1 Specification sections, apply to work of this section.

AK. Division—26 Basic Materials and Methods sections apply to work specified in this section. 1.2 DESCRIPTION OF WORK

AL. Extent of telephone and computer system work is indicated by drawings and is hereby defined to include, but not be limited to raceway, j-boxes, outlets, device plates, backboards, cabinets, grounding and miscellaneous items required for complete raceway system. AM. Refer to other Division-26 sections for requirements for raceways, trays, boxes and fittings, wiring devices (plates), and

AN. Comply with applicable portions of NEC as to type products used and installation of components. Provide products and materials which have been UL-listed and labeled.

PART 2 - PRODUCTS AO. General: Provide complete raceway system for telephone and computer including but not limited to, raceway, j-boxes, outlets, device plates, backboards, cabinets, grounding and miscellaneous items as required.

PART 3 - EXECUTION 3.1 INSTALLATION OF TELEPHONE AND COMPUTER RACEWAY SYSTEM

END OF SECTION 26 0740

AQ. General: Install raceway system as indicated to comply with NEC and recognized industry practices. Run 3/4" conduit from each outlet to terminal backboard, tray, or terminal cabinet or as otherwise noted. Provide nylon pull cord in all installed raceways. Install cover plates.

II y ottling Milking 547 We DRAWN BY Josh Smith DATE 10/27/25 SHEET Electrical Notes SCALE **14** of **14**