

KEYED NOTES

1. -

SKYLodge

UPDATE



PROFESSIONAL SEAL

SHEET NAME
ELECTRICAL SITE
PLANDraftsman Phase SCHEMATIC DESIGN
GVI Approval Project No. 22122
Client Approval File deg
Date Code

SCALE

SHEET NUMBER

ES101

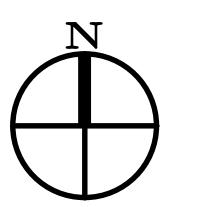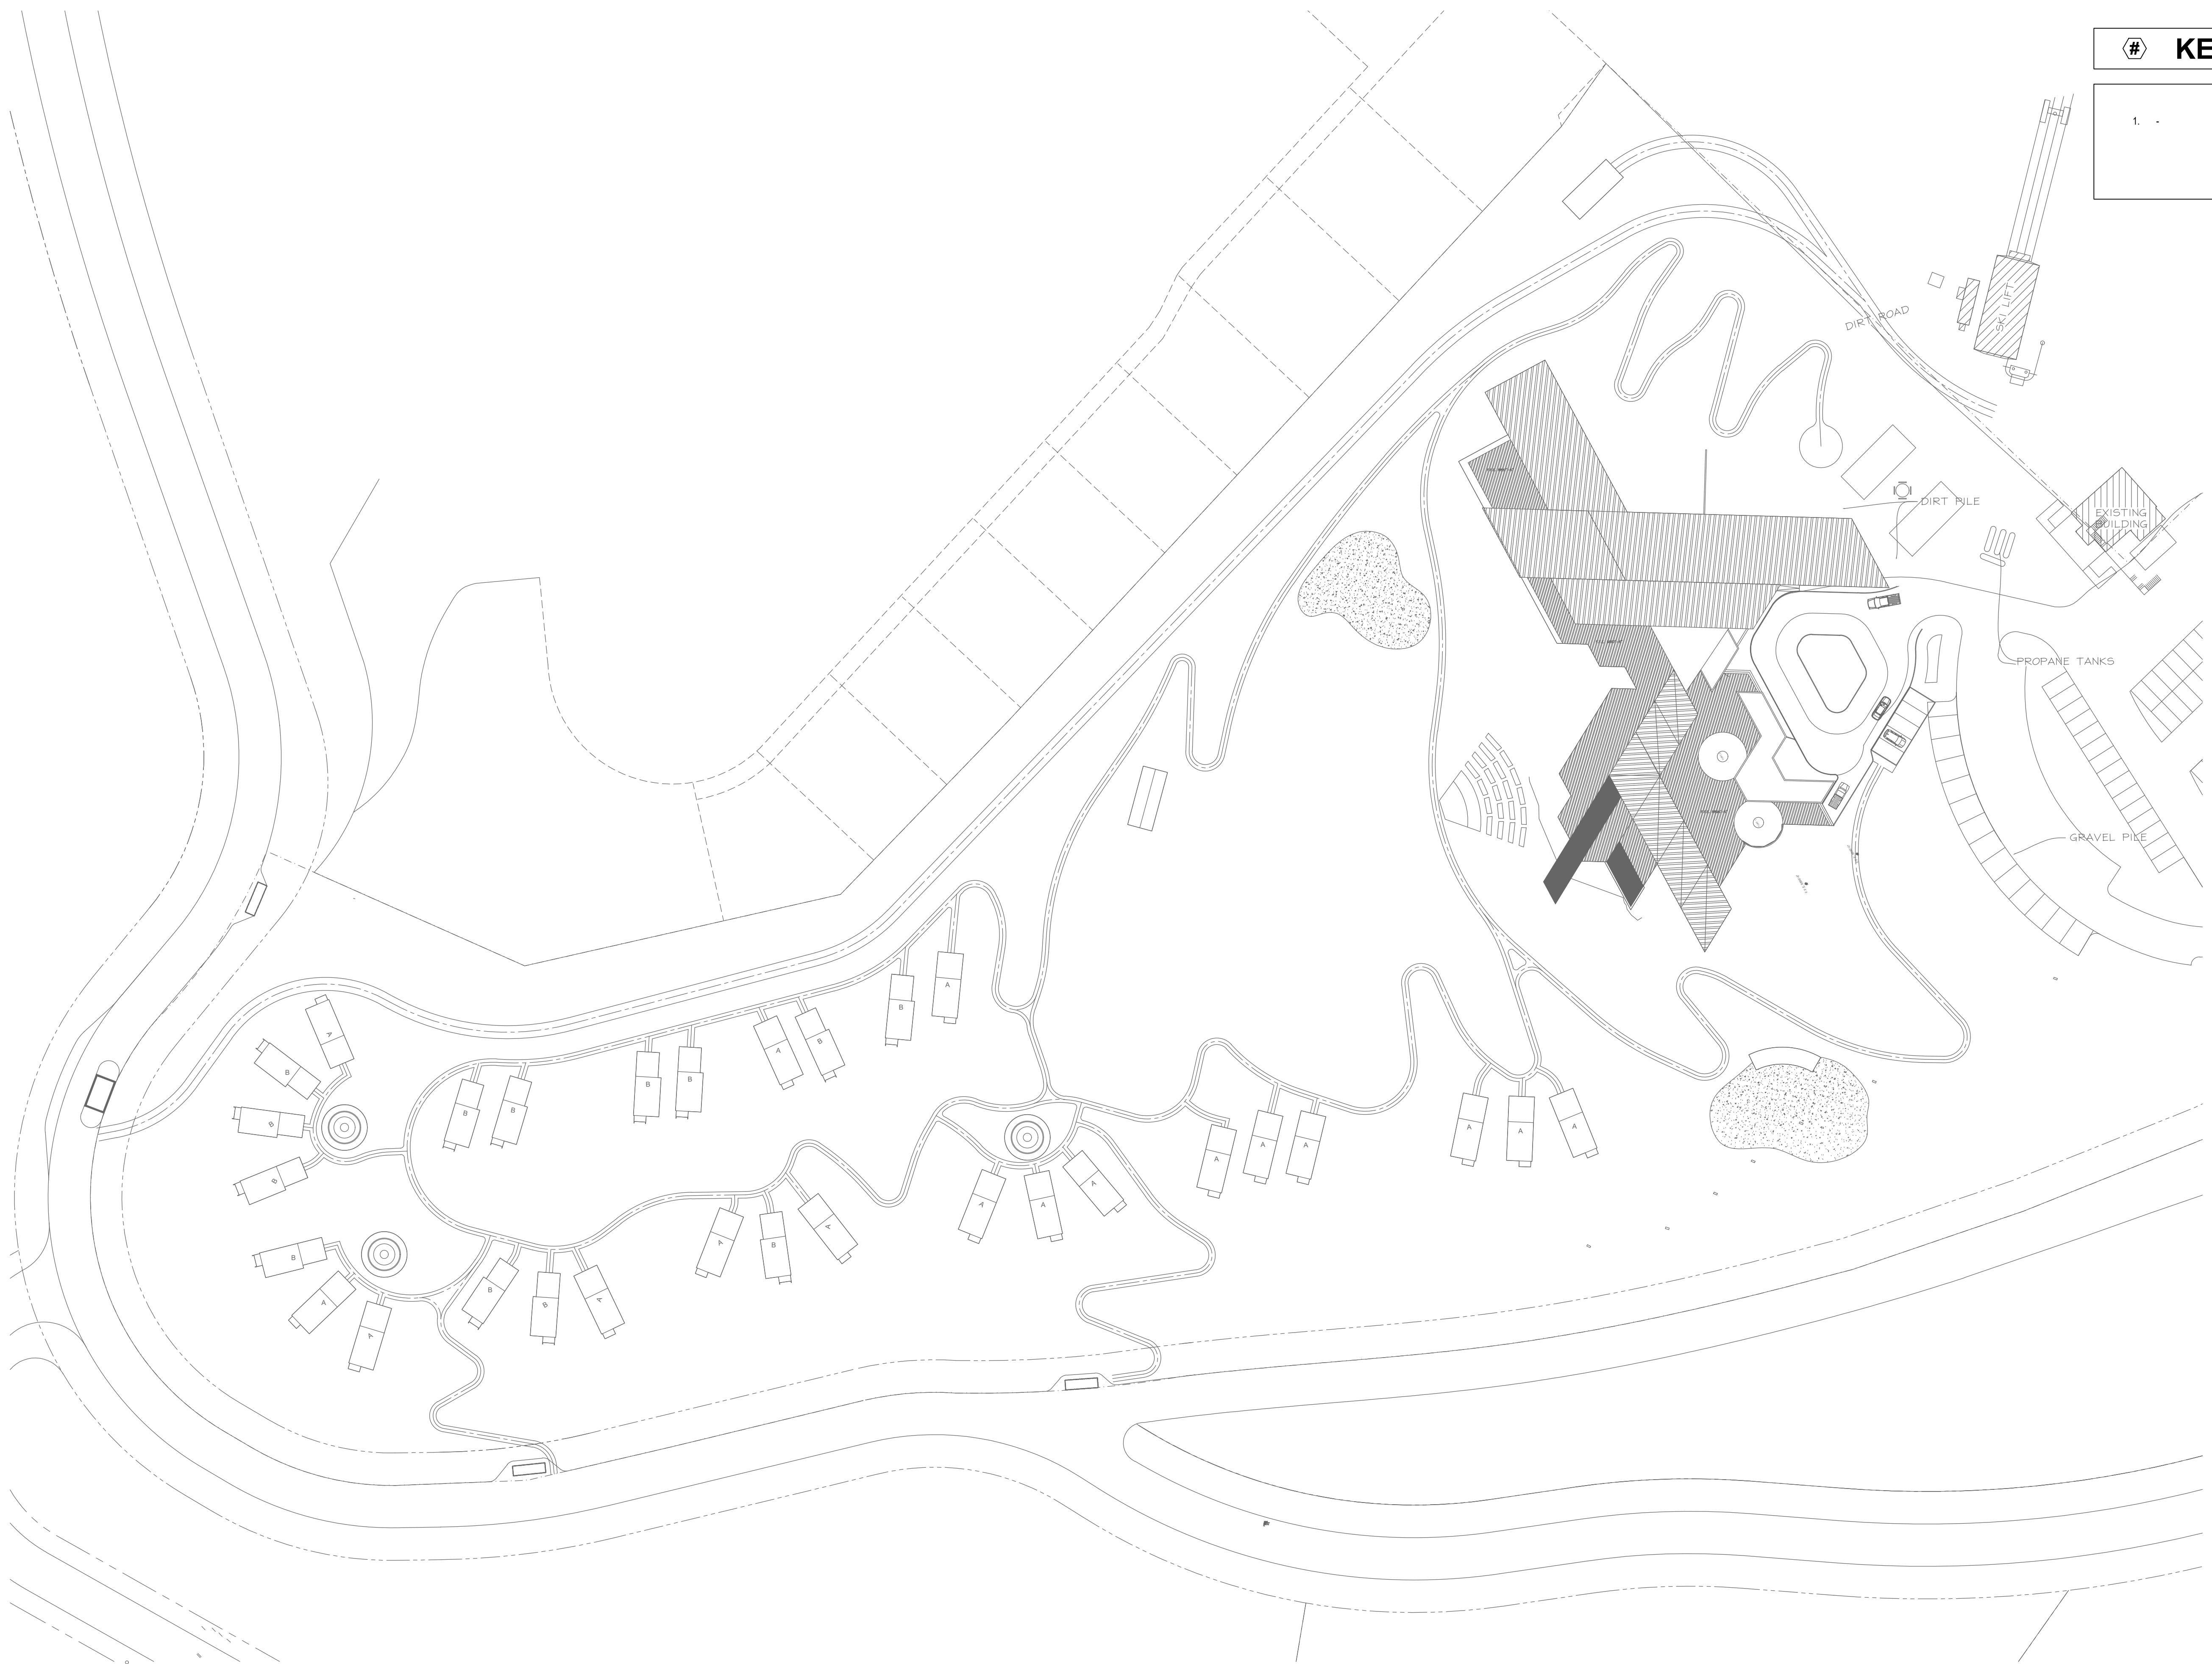1 ELECTRICAL SITE PLAN
ES101 SCALE: 1"-50'-0"

1 2 3 4 5 6 7 8 9 10 11 12 13 14 15 16



MRP LED
LED Area Luminaire

Catalog Number _____
Notes _____
Type _____

Fit the Tab key or mouse over the page to see all interactive elements.

Capable Luminaire

This item is an A+ capable luminaire, which has been designed and tested to provide consistent color appearance and system-level interoperability.

- All configurations of this luminaire meet the Acuity Brands' specification for chromatic consistency
- This luminaire is A+ Certified when ordered with DTL DLL controls marked by a shaded background. DTL DLL equipped luminaires meet the A+ specification for luminaire to photocell interoperability¹
- This luminaire is part of an A+ Certified solution for ROAM® or XPoint™ Wireless control networks, providing out-of-the-box control compatibility with simple commissioning, when ordered with drivers and control options marked by a shaded background²

To learn more about A+, visit www.acuitybrands.com/aplus.

- See ordering tree for details.
- A+ Certified Solutions for ROAM require the order of one ROAM node per luminaire. Sold Separately: [Link to Roam](#); [Link to DTL DLL](#).

A+ Capable options indicated by this color background.

Ordering Information

EXAMPLE: MRP LED 42C 700 40K SR5 MVOLT DDBXD						
MRP LED	LEDs	Drive current	Color temperature	Distribution	Voltage	Mounting
MRP LED	42	42 LEDs (one engine)	350 350mA	30K 3000K	SR3 Type II	MVOLT
			700 700mA	40K 4000K	SR3 Type III	277
			1000 1000mA (1A)	50K 5000K	SR4 Type IV	347
				208°	SR5 Type V	400°

Control options

Shipped installed	Other options	Finish request
PER NEMA twist-lock receptacle only (control ordered separate)	SF Single face (100, 277, 347) ¹	DBR10D Brushed bronze
PERS Five-wire receptacle only (control ordered separate)	DF Double face (208, 240, 480) ¹	DBL10D Textured black
PER7 Seven-wire receptacle only (control ordered separate)	PMNT03 Part night, dim till down ¹	DNAXD Natural aluminum
	PMNT103 Part night, dim 5 hrs ¹	DWHD White
	PMNT163 Part night, dim 6 hrs ¹	
	PMNT703 Part night, dim 7 hrs ¹	DWHQD Textured white

Fixture will be mounted on 10'-0" pole on top of 5'-0" concrete base.

LITHONIA LIGHTING
COMMERCIAL OUTDOOR

One Lithonia Way • Conyers, Georgia 30012 • Phone: 800-705-SERV (7378) • www.lithonia.com
© 2011-2022 Acuity Brands Lighting, Inc. All rights reserved.
MRP-LED
Rev. 03/08/22

N 1 ES102 SCALE: 1'=50'-0"

PHOTOMETRIC OVERALL PLAN

Fire Department Hookups

Average	0.9 fc
Maximum	1.5 fc
Minimum	0.1 fc

Sidewalks

Average	1.5 fc
Maximum	4.1 fc
Minimum	0.1 fc

Front Entry

Average	1.8 fc
Maximum	4.3 fc
Minimum	0.1 fc

ES102

SKYLodge


UPDATE

PROFESSIONAL SEAL

SHEET NAME
PHOTOMETRIC OVERALL PLAN

SCALE
Sheet Number
ES102

Draftsman Phase SCHEMATIC DESIGN
GVI Approval Project No. 22122
Client Approval File .dwg
Date Code

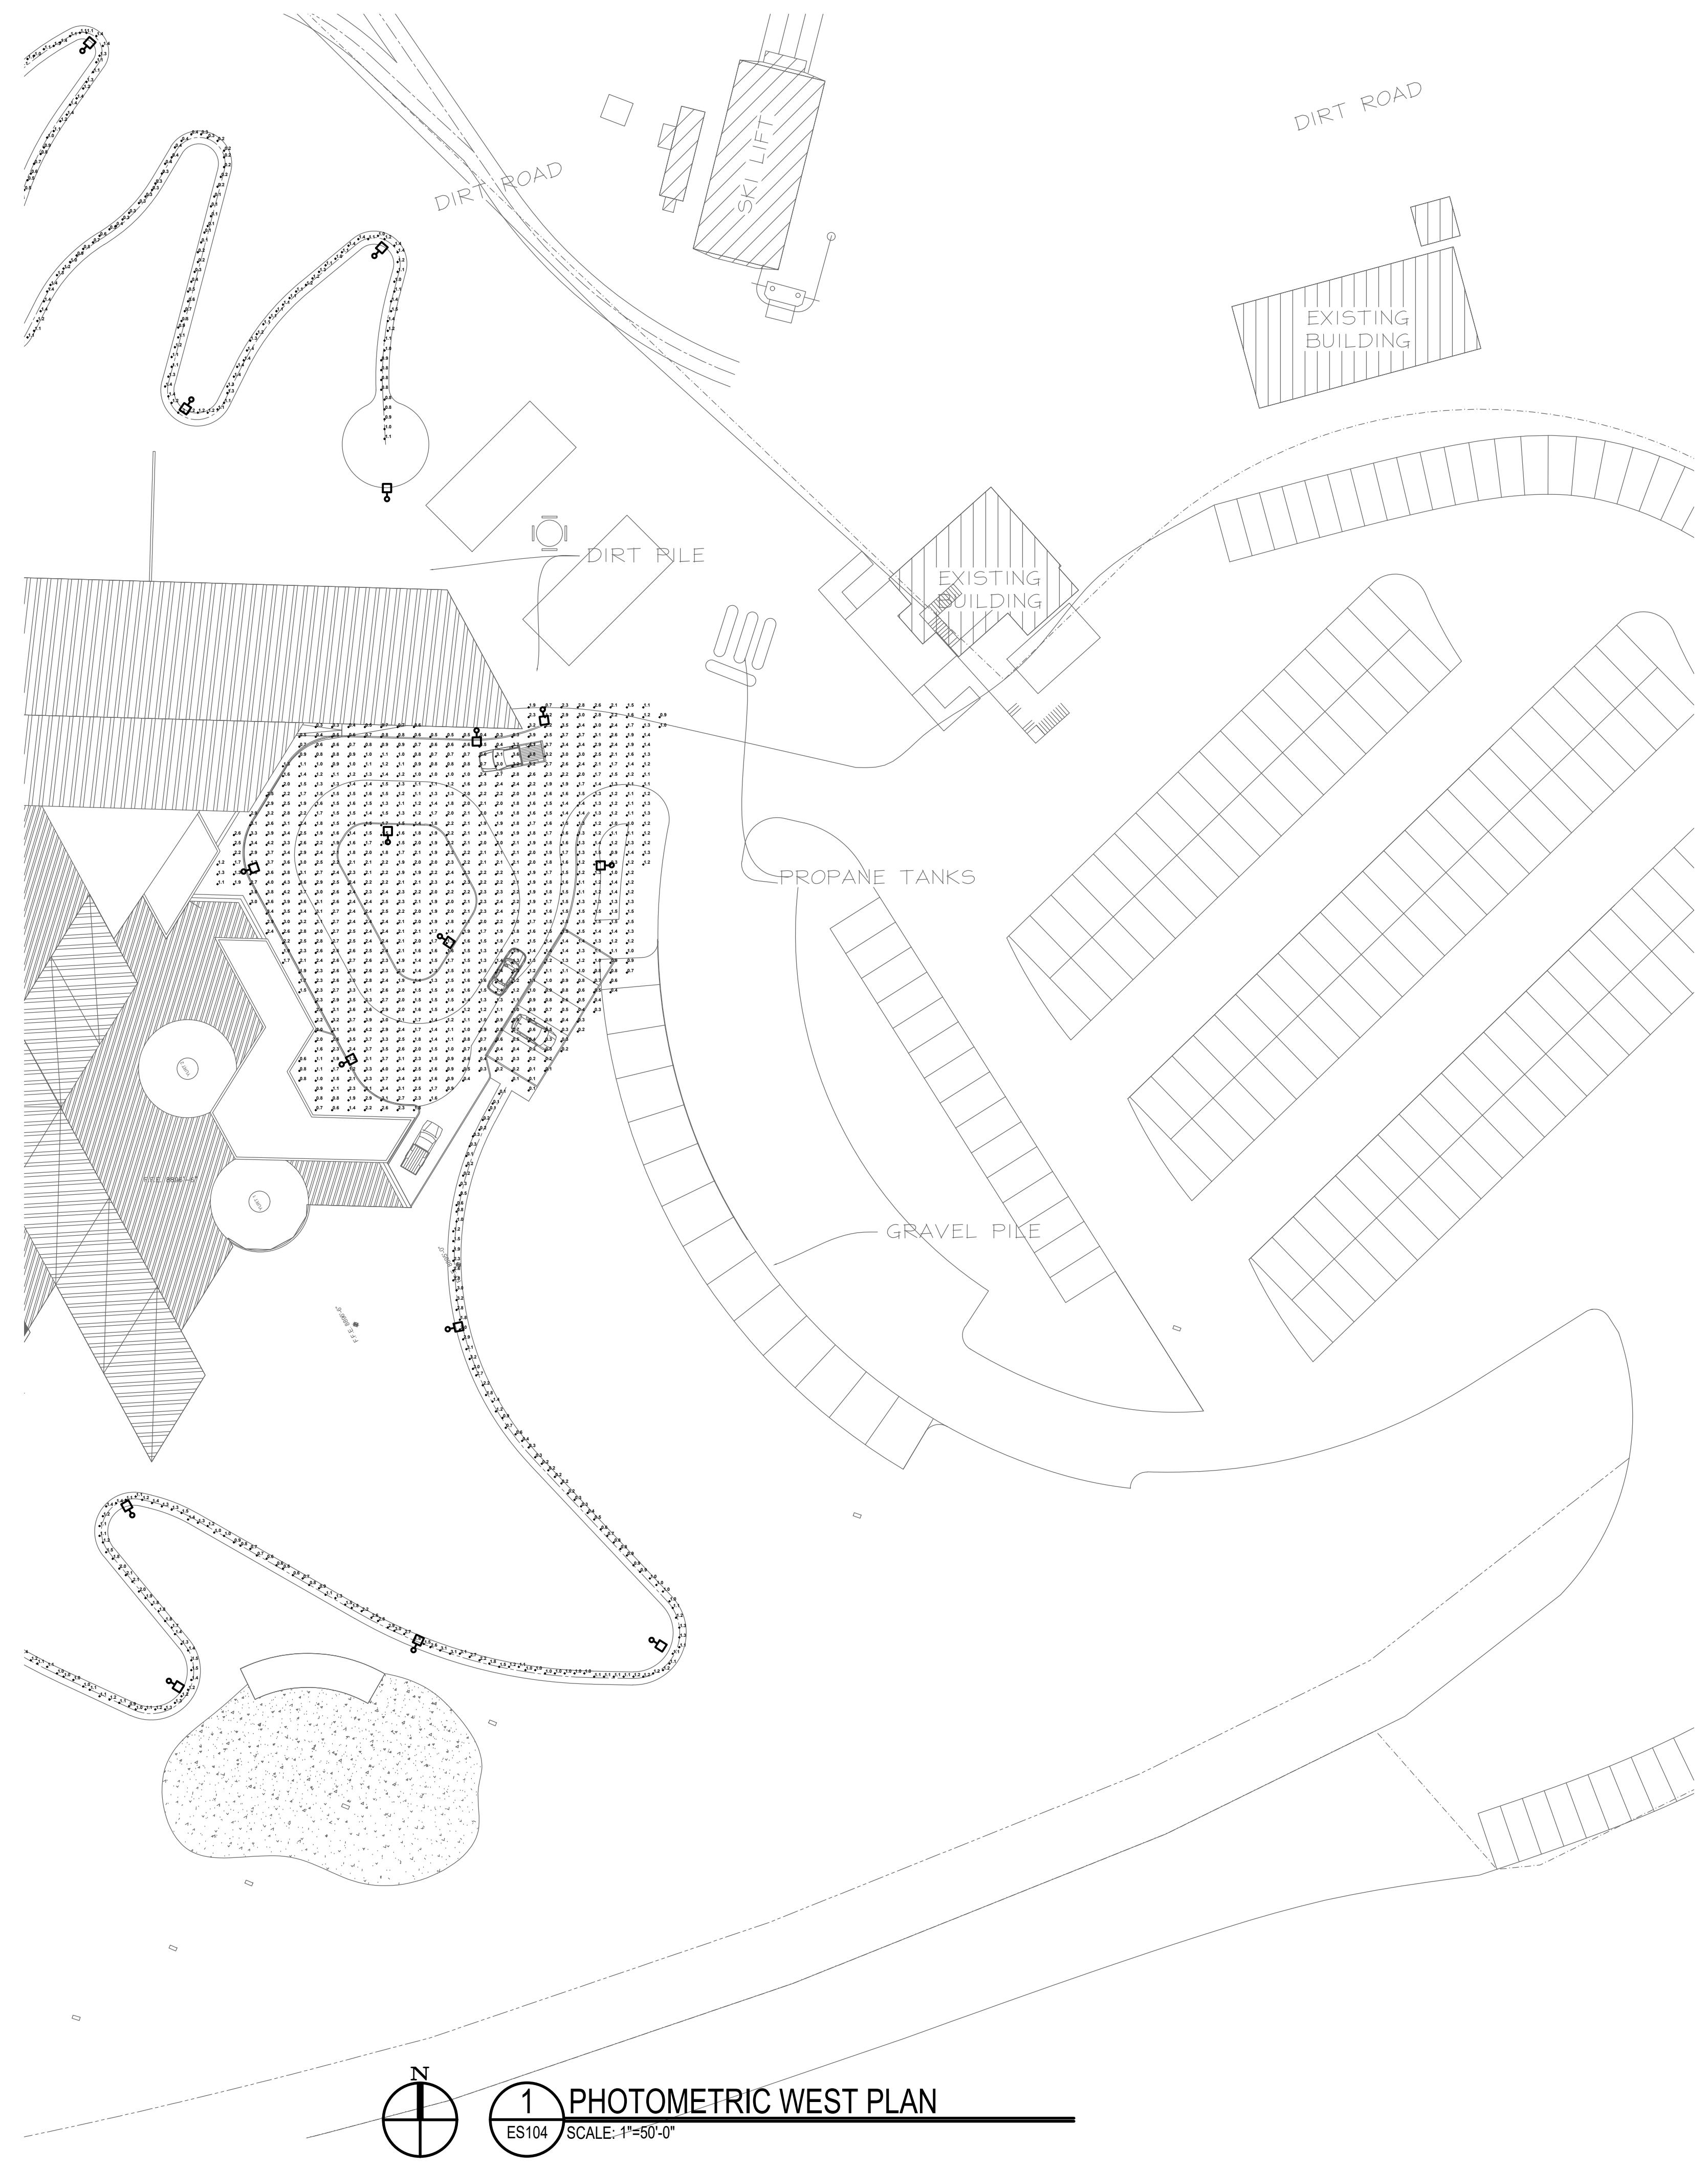

GOMEZ VAZQUEZ
INTERNATIONAL

ARCHITECTURE | PLANNING | URBAN DESIGN

210-404-9658 www.gvi.archi

ISSUED SETS

Date	Description


REVISIONS

No.	Date	Description

SKYLodge

UPDATE

 PROFESSIONAL SEAL



SHEET NAME
**PHOTOMETRIC WEST
PLAN**

Draftsman Phase SCHEMATIC DESIGN
GVI Approval Project No. 22122
Client Approval File deg
Date Code

SCALE

SHEET NUMBER

ES104

1 2 3 4 5 6 7 8 9 10 11 12 13 14 15 16

1 2 3 4 5 6 7 8 9 10 11 12 13 14 15 16